


LEGENDS:-

SYMBOL	DESCRIPTION
	MAIN DISTRIBUTION BOARD (MDB) IP55
	SUB MAIN DISTRIBUTION BOARD
	DISTRIBUTION BOARD (DB)
	CAPACITOR BANK
	LIGHTING CONTROL PANEL
	SINGLE PHASE ISOLATOR IP65
	THREE PHASE ISOLATOR IP65
	13A SINGLE SOCKET SINGLE SWITCHED OUTLET
	13A DOUBLE SOCKET SINGLE SWITCHED OUTLET
	20A SOCKET OUTLET
	SWITCHED FUSED SPUR OUTLET
	20A SOCKET OUTLET WITH DP SWITCH
	13A POLE & EARTH WEATHER PROOF SWITCH SOCKET OUTLET
	POWER CIRCUIT
	20A DP SWITCH WITH NEON INDICATOR WH/WHM/DRY/ERAC

NO.	DATE	BY	REVISION DETAILS
REVISIONS			
PROJECT: G+2 (12 NOS. TOWN HOUSES) BLOCK: AL BARSHA SOUTH 4TH PLOT: 6817078			
CLIENT: PACIFIQUE GLOBAL PROPERTIES LLC			
CONSULTANT :  PARADISE HOME ENGINEERING CONSULTANCY Architecture & Engg. Consultants DUBAI Tel: 3575333 Fax: 3575353 P.O. Box 22563			
MEP CONSULTANT:  BEC MEP DESIGN SUPERVISION P.O. Box : 114535, Dubai, U.A.E. Tel. : +971 4 2662650, Fax : +971 4 2662680, blazemiddleeast@gmail.com www.blazeengineeringme.com			
MAIN CONT. :  VISION HOUSE BUILDING CONTRACTING LLC فيجين هاوس لمقاولات البناء (ش.م.ج.) VISION HOUSE BUILDING CONTRACTING LLC P.O. BOX: 1909, DUBAI TEL: 04-2343355 FAX: 04-2343377			
MEP CONT. : ELECTRIC CIRCLE TECHNICAL SERVICES LLC P.O. BOX 232522, DUBAI TEL: 042871919 FAX: 042870909 M: 0556452851 Email: electriccircle@gmail.com			
DRAWING TITLE SETTING OUT POWER PLAN			
DATE : 17/06/2024	DESIGN: R.A.	DRAWING NO. EP-100	
SCALE : 1:150	REVISION: 00		

SETTING OUT PLAN

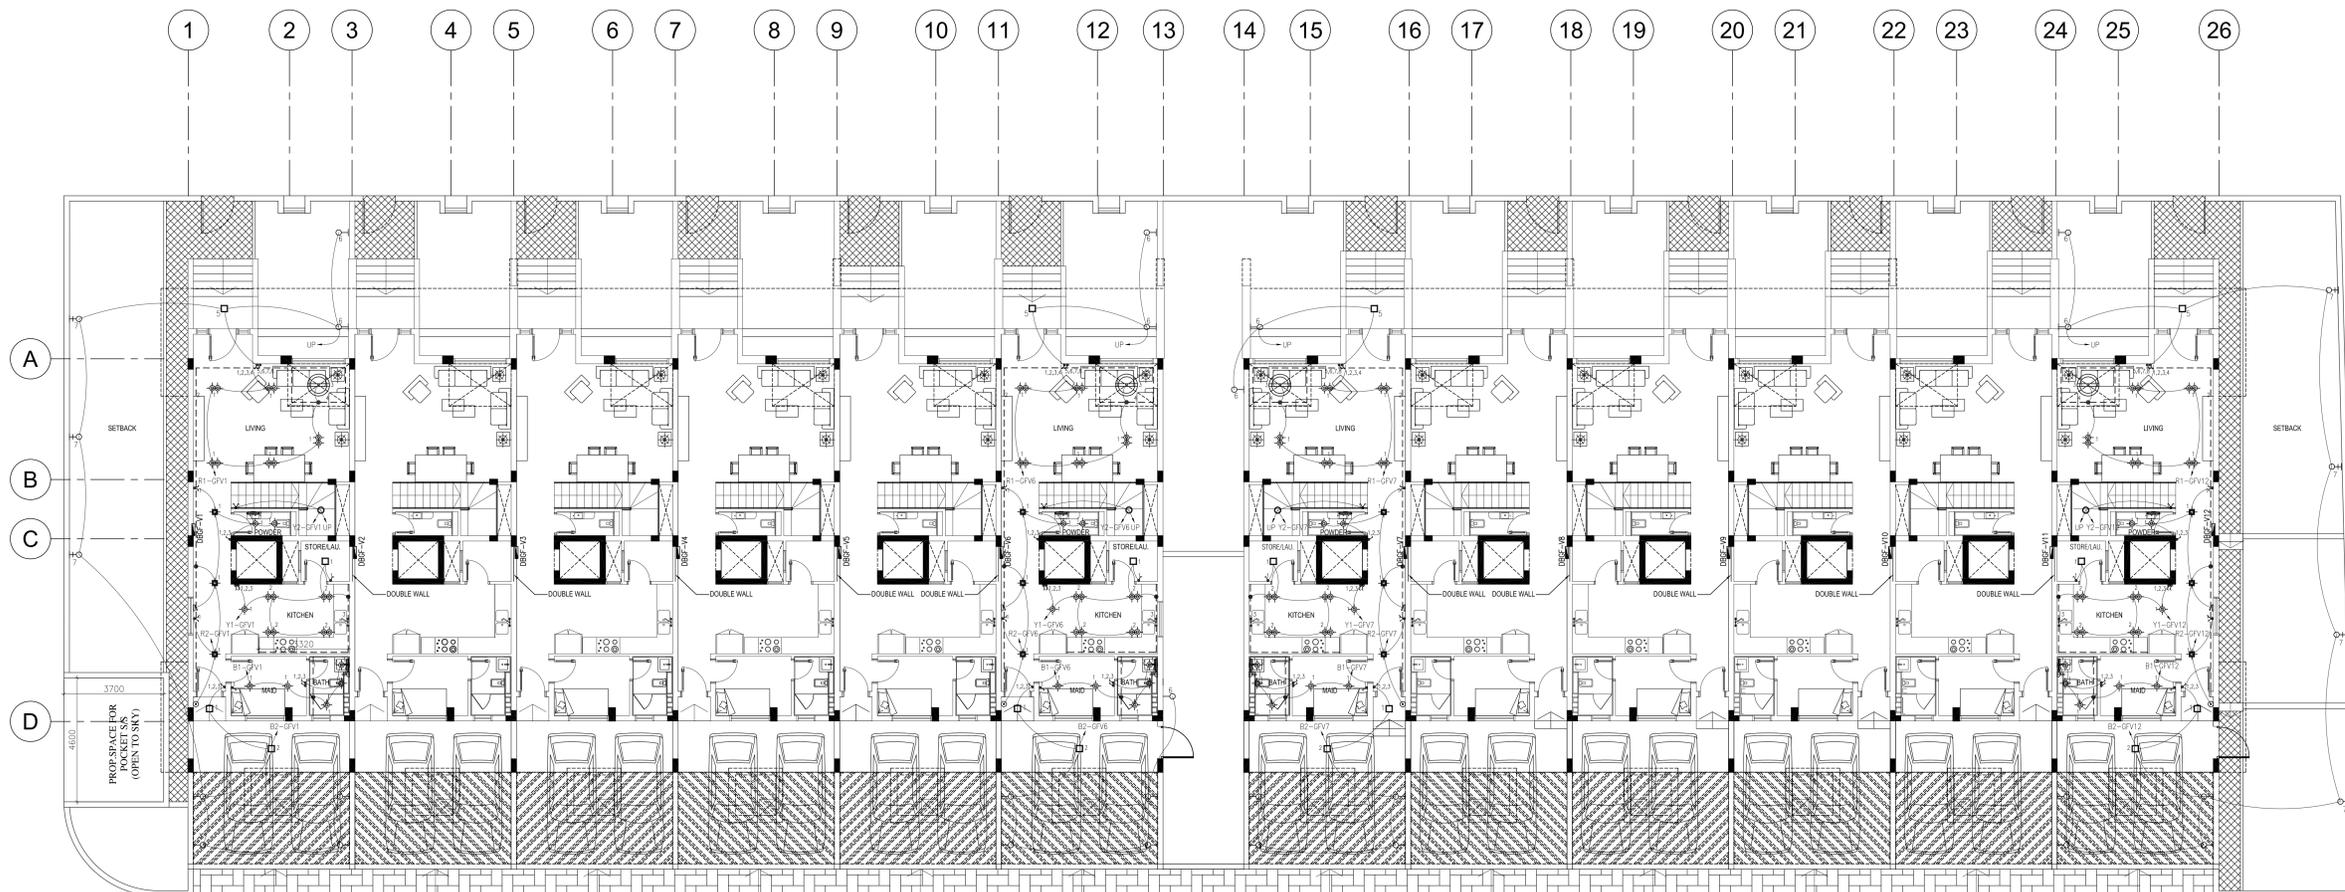


GROUND FLOOR LIGHTING LAYOUT PLAN

LEGEND	
SYMBOL	DESCRIPTION
	6W MODERN ALUMINUM WHITE CEILING SPOT LIGHT
	LED COVE LIGHT
	CHANDELIER LIGHT
	8W LED OUTDOOR WALL LIGHT
	20W OUTDOOR LED GRILL WALL LIGHT WATER PROOF
	20W SQUARE SURFACE MOUNTED LED PANEL
	8W TRIMLESS ROUND ADJUSTABLE 360 MATT WHITE 3000K
	8W 3000K LED RECESSED DOWNLIGHT ANTI-GLARE ADJUSTABLE DIRECTION: 360° BEAM ANGLE: 45°
	MIRROR LED STRIP LIGHT
	SHAVER SOCKET
	CALL BELL
	PUSH BUTTON DOOR BELL
	INLINE DUCTED TYPE EXHAUST FAN
	ONE WAY LIGHT SWITCH
	TWO WAY LIGHT SWITCH
	ONE WAY LIGHT SWITCH WEATHER PROOF TYPE
	TWO WAY LIGHT SWITCH WEATHER PROOF TYPE
	LIGHT CIRCUIT


NO.	DATE	BY	REVISION DETAILS
REVISIONS			
PROJECT:			
G+2 (12 NOS. TOWN HOUSES)			
BLOCK: AL BARSHA SOUTH 4TH PLOT: 6817078			
CLIENT:			
PACIFIQUE GLOBAL PROPERTIES LLC			
CONSULTANT :			
 <b>PARADISE HOME ENGINEERING CONSULTANCY</b> Architecture & Engg. Consultants DUBAI Tel: 3575333 Fax: 3575353 P.O. Box 22563			
MEP CONSULTANT:			
 <b>BEC</b> MEP DESIGN SUPERVISION			
P.O. Box : 114535, Dubai, U.A.E. Tel. : +971 4 2662650, Fax : +971 4 2662680, blazemiddleeast@gmail.com www.blazeengineeringme.com			
MAIN CONT. :			
 <b>VISION HOUSE BUILDING CONTRACTING LLC</b> (ش.م.م) فيجيين هاوس لمخاولات البناء VISION HOUSE BUILDING CONTRACTING LLC			
VISION HOUSE BUILDING CONTRACTING P.O. BOX: 1909, DUBAI TEL: 04-2343355 FAX: 04-2343377			
MEP CONT. :			
ELECTRIC CIRCLE TECHNICAL SERVICES LLC P.O. BOX 232522, DUBAI TEL: 042871919 FAX: 042870909 M: 0556452851 Email: electriccirclellc@gmail.com			
DRAWING TITLE			
GROUND FLOOR LIGHTING LAYOUT PLAN			
DATE :	DESIGN: R.A.	DRAWING NO.	
17/06/2024		EL-101	
SCALE : 1:150	REVISION: 00		

LEGEND	
SYMBOL	DESCRIPTION
	6W MODERN ALUMINUM WHITE CEILING SPOT LIGHT
	LED COVE LIGHT
	CHANDELIER LIGHT
	8W LED OUTDOOR WALL LIGHT
	20W OUTDOOR LED GRILL WALL LIGHT WATER PROOF
	20W SQUARE SURFACE MOUNTED LED PANEL
	8W TRIMLESS ROUND ADJUSTABLE 360 MATT WHITE 3000K
	8W 3000K LED RECESSED DOWNLIGHT ANTI-GLARE ADJUSTABLE DIRECTION: 360° BEAM ANGLE: 45°
	MIRROR LED STRIP LIGHT
	SHAVER SOCKET
	CALL BELL
	PUSH BUTTON DOOR BELL
	INLINE DUCTED TYPE EXHAUST FAN
	ONE WAY LIGHT SWITCH
	TWO WAY LIGHT SWITCH
	ONE WAY LIGHT SWITCH WEATHER PROOF TYPE
	TWO WAY LIGHT SWITCH WEATHER PROOF TYPE
	LIGHT CIRCUIT

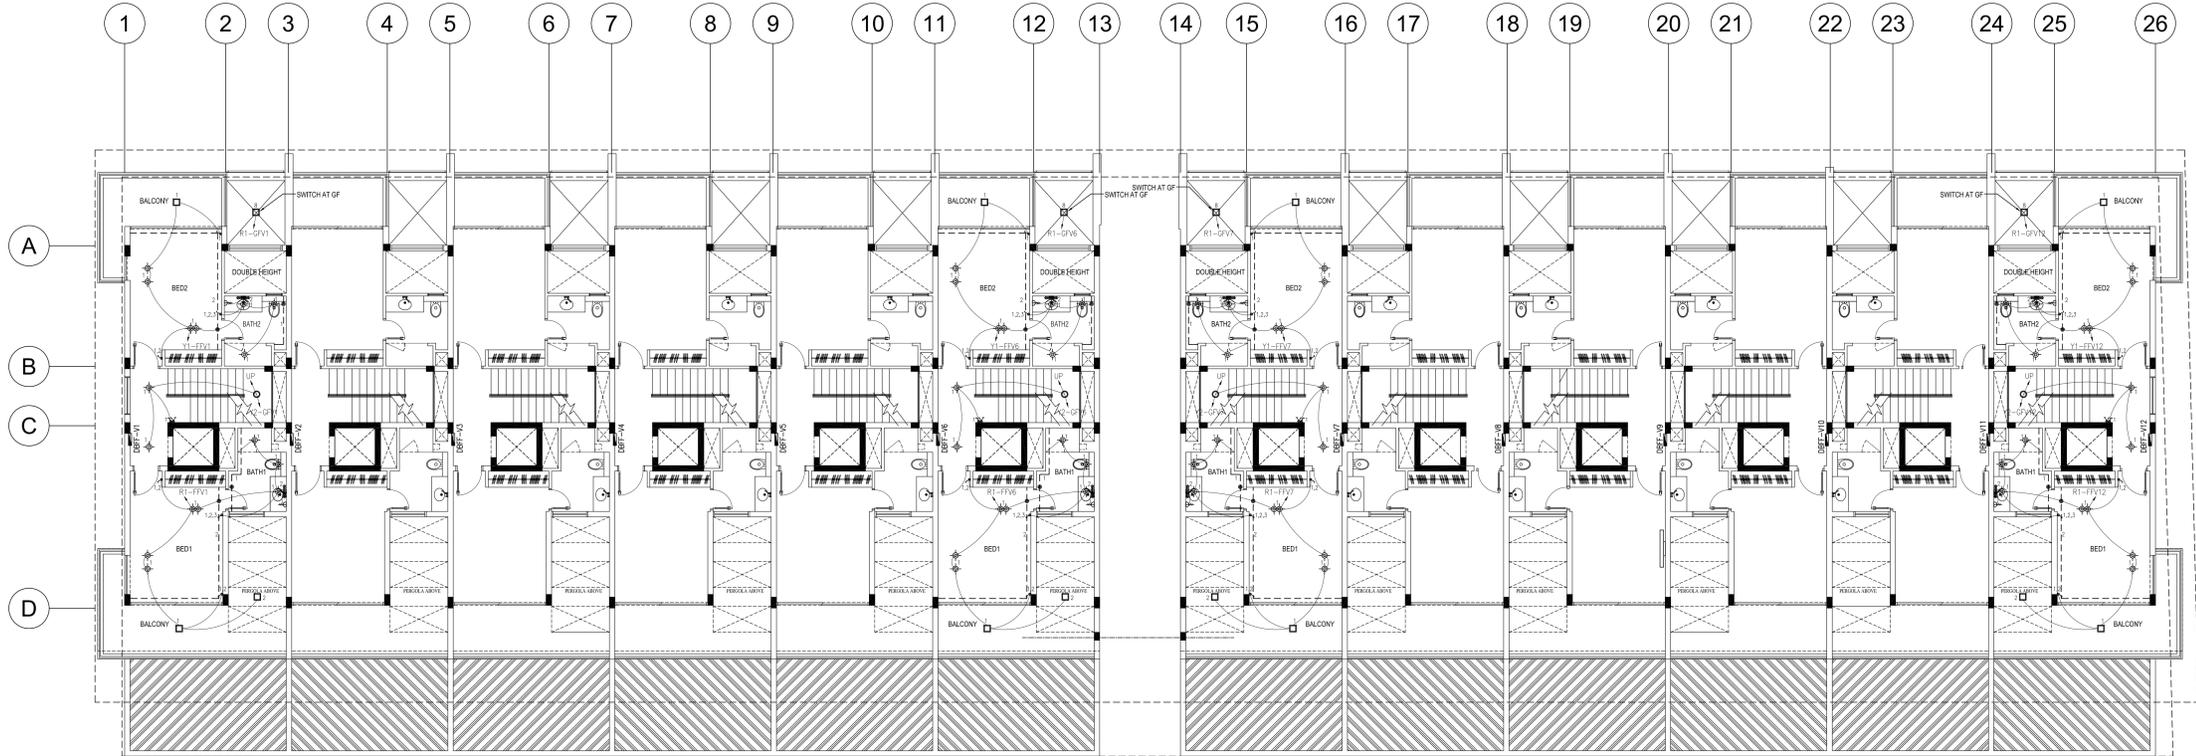

FIRST FLOOR LIGHTING LAYOUT PLAN

NO.	DATE	BY	REVISION DETAILS
REVISIONS			
PROJECT:			
G+2 (12 NOS. TOWN HOUSES)			
BLOCK: AL BARSHA SOUTH 4TH PLOT: 6817078			
CLIENT:			
PACIFIQUE GLOBAL PROPERTIES LLC			
CONSULTANT :			
 <b>PARADISE HOME ENGINEERING CONSULTANCY</b> Architecture & Engg. Consultants DUBAI Tel: 3575333 Fax: 3575353 P.O. Box 22563			
MEP CONSULTANT:			
 <b>BEC</b> MEP DESIGN SUPERVISION			
P.O. Box : 114535, Dubai, U.A.E. Tel. : +971 4 2662650, Fax : +971 4 2662680, blazemiddleeast@gmail.com www.blazeengineeringme.com			
MAIN CONT. :			
 <b>VISION HOUSE</b> Building Contracting LLC			
VISION HOUSE BUILDING CONTRACTING P.O. BOX: 1909, DUBAI TEL: 04-2343355 FAX: 04-2343377			
MEP CONT. :			
ELECTRIC CIRCLE TECHNICAL SERVICES LLC P.O. BOX 232522, DUBAI TEL: 042871919 FAX: 042870909 M: 0556452851 Email: electriccirclellc@gmail.com			
DRAWING TITLE			
FIRST FLOOR LIGHTING LAYOUT PLAN			
DATE :	DESIGN: R.A.	DRAWING NO.	
17/06/2024		EL-102	
SCALE : 1:150	REVISION: 00		

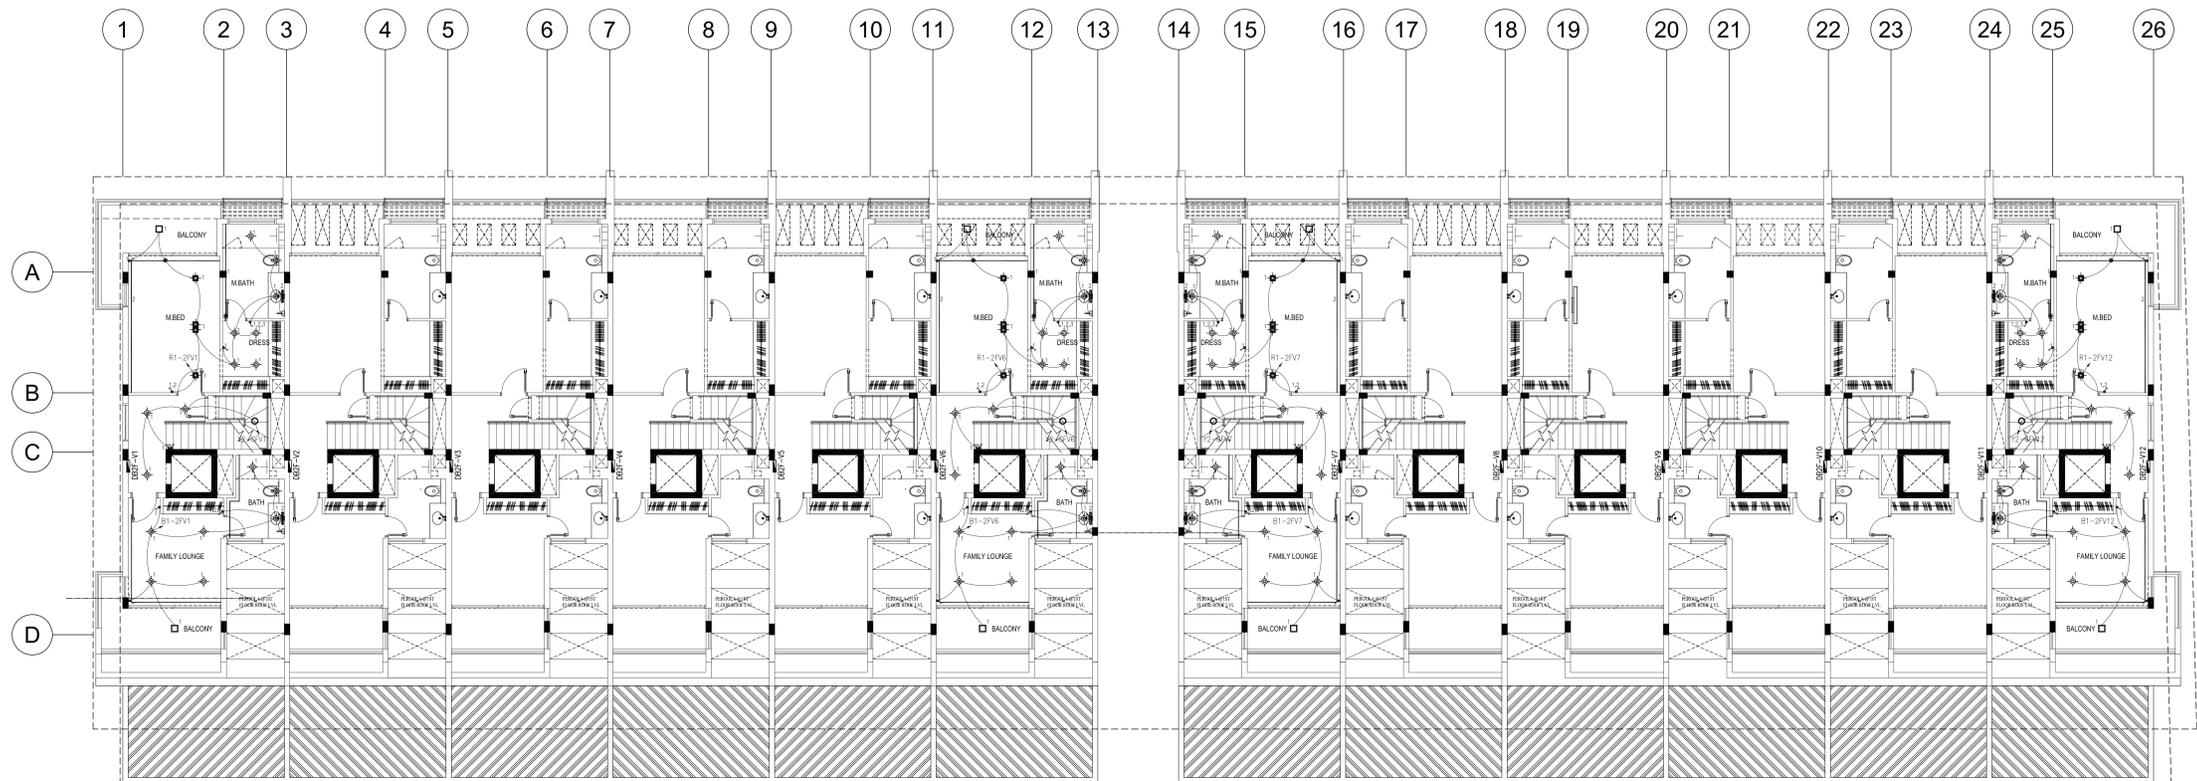


SECOND FLOOR LIGHTING LAYOUT PLAN

LEGEND	
SYMBOL	DESCRIPTION
	6W MODERN ALUMINUM WHITE CEILING SPOT LIGHT
	LED COVE LIGHT
	CHANDELIER LIGHT
	8W LED OUTDOOR WALL LIGHT
	20W OUTDOOR LED GRILL WALL LIGHT WATER PROOF
	20W SQUARE SURFACE MOUNTED LED PANEL
	8W TRIMLESS ROUND ADJUSTABLE 360 MATT WHITE 3000K
	8W 3000K LED RECESSED DOWNLIGHT ANTI-GLARE ADJUSTABLE DIRECTION: 360° BEAM ANGLE: 45°
	MIRROR LED STRIP LIGHT
	SHAVER SOCKET
	CALL BELL
	PUSH BUTTON DOOR BELL
	INLINE DUCTED TYPE EXHAUST FAN
	ONE WAY LIGHT SWITCH
	TWO WAY LIGHT SWITCH
	ONE WAY LIGHT SWITCH WEATHER PROOF TYPE
	TWO WAY LIGHT SWITCH WEATHER PROOF TYPE
	LIGHT CIRCUIT

NO.	DATE	BY	REVISION DETAILS
REVISIONS			
PROJECT:			
G+2 (12 NOS. TOWN HOUSES)			
BLOCK: AL BARSHA SOUTH 4TH PLOT: 6817078			
CLIENT:			
PACIFIQUE GLOBAL PROPERTIES LLC			
CONSULTANT :			
 <b>PARADISE HOME ENGINEERING CONSULTANCY</b> Architecture & Engg. Consultants DUBAI Tel: 3575333 Fax: 3575353 P.O. Box 22563			
MEP CONSULTANT:			
 <b>BEC</b> MEP DESIGN SUPERVISION P.O. Box : 114535, Dubai, U.A.E. Tel. : +971 4 2662650, Fax : +971 4 2662680, blazemiddleeast@gmail.com www.blazeengineeringme.com			
MAIN CONT. :			
 <b>VISION HOUSE BUILDING CONTRACTING LLC</b> فيجين هاوس لمقاولات البناء (ش.ذ.م.) VISION HOUSE BUILDING CONTRACTING LLC P.O. BOX: 1909, DUBAI TEL: 04-2343355 FAX: 04-2343377			
MEP CONT. :			
<b>ELECTRIC CIRCLE TECHNICAL SERVICES LLC</b> P.O. BOX 232522, DUBAI TEL: 042871919 FAX: 042870909 M: 0556452851 Email: electriccirclellc@gmail.com			
DRAWING TITLE			
SECOND FLOOR LIGHTING LAYOUT PLAN			
DATE :	DESIGN: R.A.	DRAWING NO.	
17/06/2024		EL-103	
SCALE : 1:150	REVISION: 00		

LEGEND	
SYMBOL	DESCRIPTION
	6W MODERN ALUMINUM WHITE CEILING SPOT LIGHT
	LED COVE LIGHT
	CHANDELIER LIGHT
	8W LED OUTDOOR WALL LIGHT
	20W OUTDOOR LED GRILL WALL LIGHT WATER PROOF
	20W SQUARE SURFACE MOUNTED LED PANEL
	8W TRIMLESS ROUND ADJUSTABLE 360 MATT WHITE 3000K
	8W 3000K LED RECESSED DOWNLIGHT ANTI-GLARE ADJUSTABLE DIRECTION: 360° BEAM ANGLE: 45°
	MIRROR LED STRIP LIGHT
	SHAVER SOCKET
	CALL BELL
	PUSH BUTTON DOOR BELL
	INLINE DUCTED TYPE EXHAUST FAN
	ONE WAY LIGHT SWITCH
	TWO WAY LIGHT SWITCH
	ONE WAY LIGHT SWITCH WEATHER PROOF TYPE
	TWO WAY LIGHT SWITCH WEATHER PROOF TYPE
	LIGHT CIRCUIT

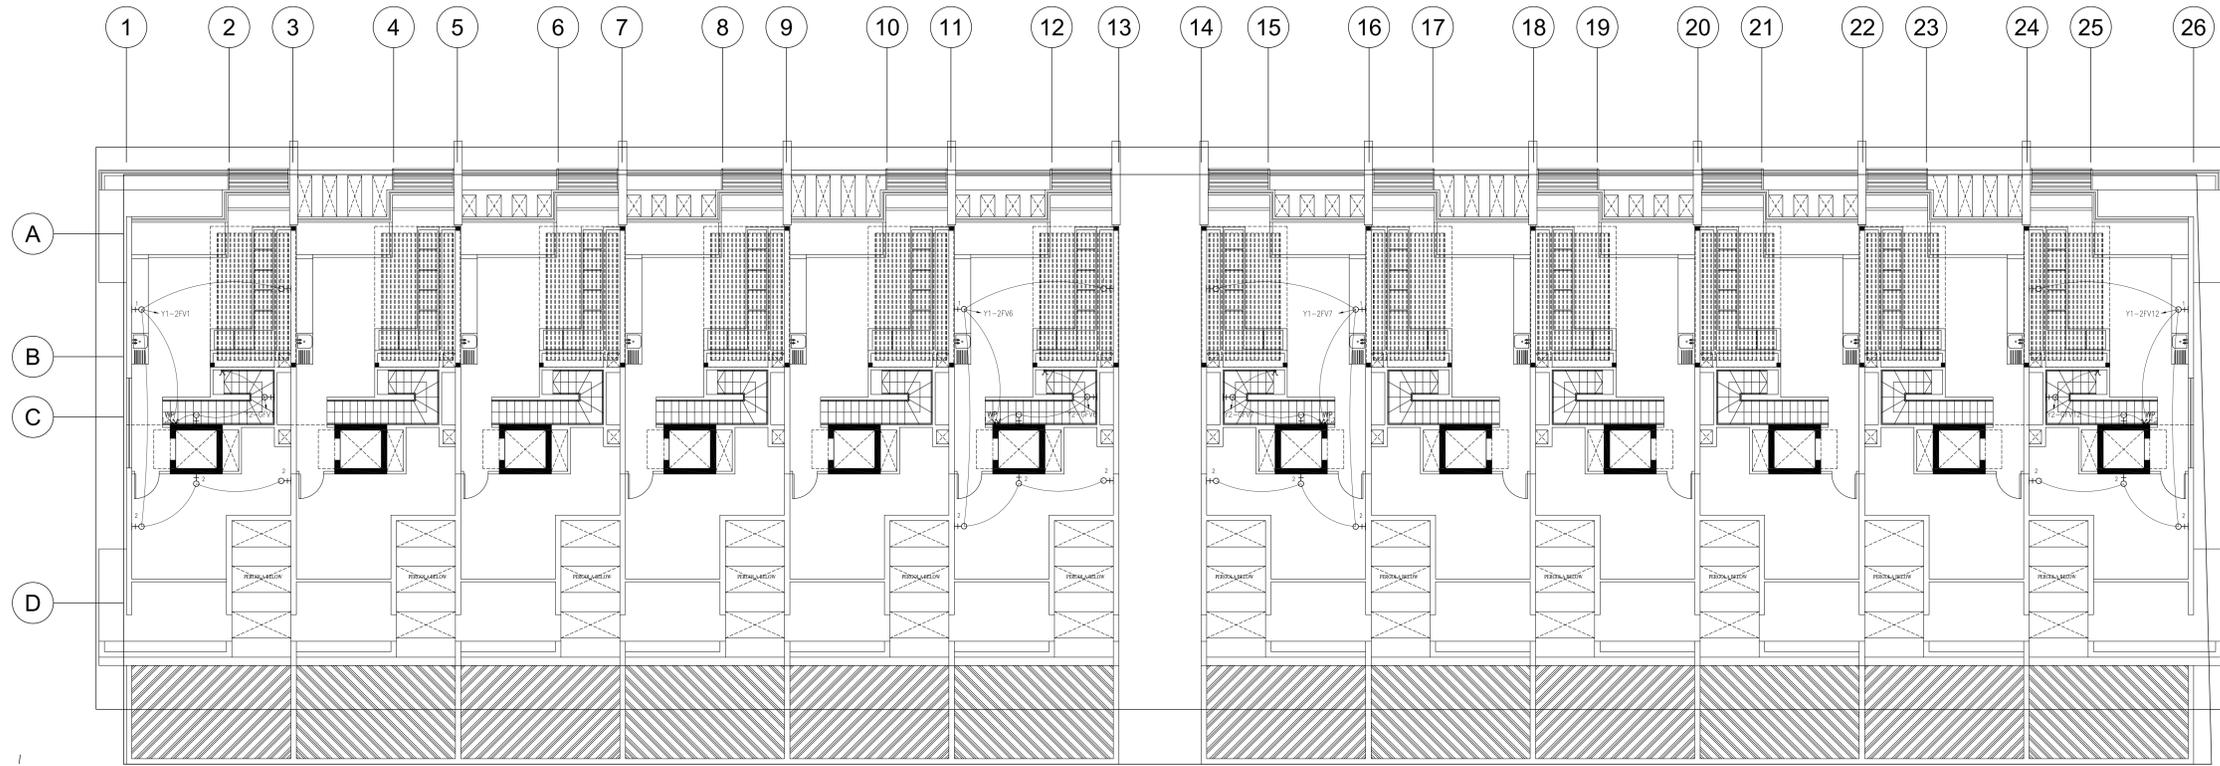


ROOF FLOOR LIGHTING LAYOUT PLAN

NO.	DATE	BY	REVISION DETAILS
REVISIONS			
PROJECT:			
G+2 (12 NOS. TOWN HOUSES)			
BLOCK: AL BARSHA SOUTH 4TH PLOT: 6817078			
CLIENT:			
PACIFIQUE GLOBAL PROPERTIES LLC			
CONSULTANT :			
 <b>PARADISE HOME ENGINEERING CONSULTANCY</b> Architecture & Engg. Consultants DUBAI Tel: 3575333 Fax: 3575353 P.O. Box 22563			
MEP CONSULTANT:			
 <b>BEC</b> MEP DESIGN SUPERVISION P.O. Box : 114535, Dubai, U.A.E. Tel. : +971 4 2662650, Fax : +971 4 2662680, blazemiddleeast@gmail.com www.blazeengineeringme.com			
MAIN CONT. :			
 <b>VISION HOUSE BUILDING CONTRACTING LLC</b> (ش.ذ.م.ج) فيجين هاوس لمقاولات البناء VISION HOUSE BUILDING CONTRACTING LLC			
VISION HOUSE BUILDING CONTRACTING			
P.O. BOX: 1909, DUBAI TEL: 04-2343355 FAX: 04-2343377			
MEP CONT. :			
ELECTRIC CIRCLE TECHNICAL SERVICES LLC			
P.O. BOX 232522, DUBAI			
TEL: 042871919 FAX: 042870909 M: 0556452851			
Email: electriccircle@gmail.com			
DRAWING TITLE			
ROOF FLOOR LIGHTING LAYOUT PLAN			
DATE :	DESIGN: R.A.	DRAWING NO.	
17/06/2024		EL-104	
SCALE : 1:150	REVISION: 00		

LEGENDS:-

SYMBOL	DESCRIPTION
	MAIN DISTRIBUTION BOARD(MDB) IP55
	SUB MAIN DISTRIBUTION BOARD
	DISTRIBUTION BOARD (DB)
	CAPACITOR BANK
	LIGHTING CONTROL PANEL
	SINGLE PHASE ISOLATOR IP65
	THREE PHASE ISOLATOR IP65
	13A SINGLE SOCKET SINGLE SWITCHED OUTLET
	13A DOUBLE SOCKET SINGLE SWITCHED OUTLET
	20A SOCKET OUTLET
	SWITCHED FUSED SPUR OUTLET
	20A SOCKET OUTLET WITH DP SWITCH
	13A 2-POLE & EARTH WEATHER PROOF SWITCH SOCKET OUTLET
	POWER CIRCUIT
	20A DP SWITCH WITH NEON INDICATOR WINDOW/DOOR/WINDOW

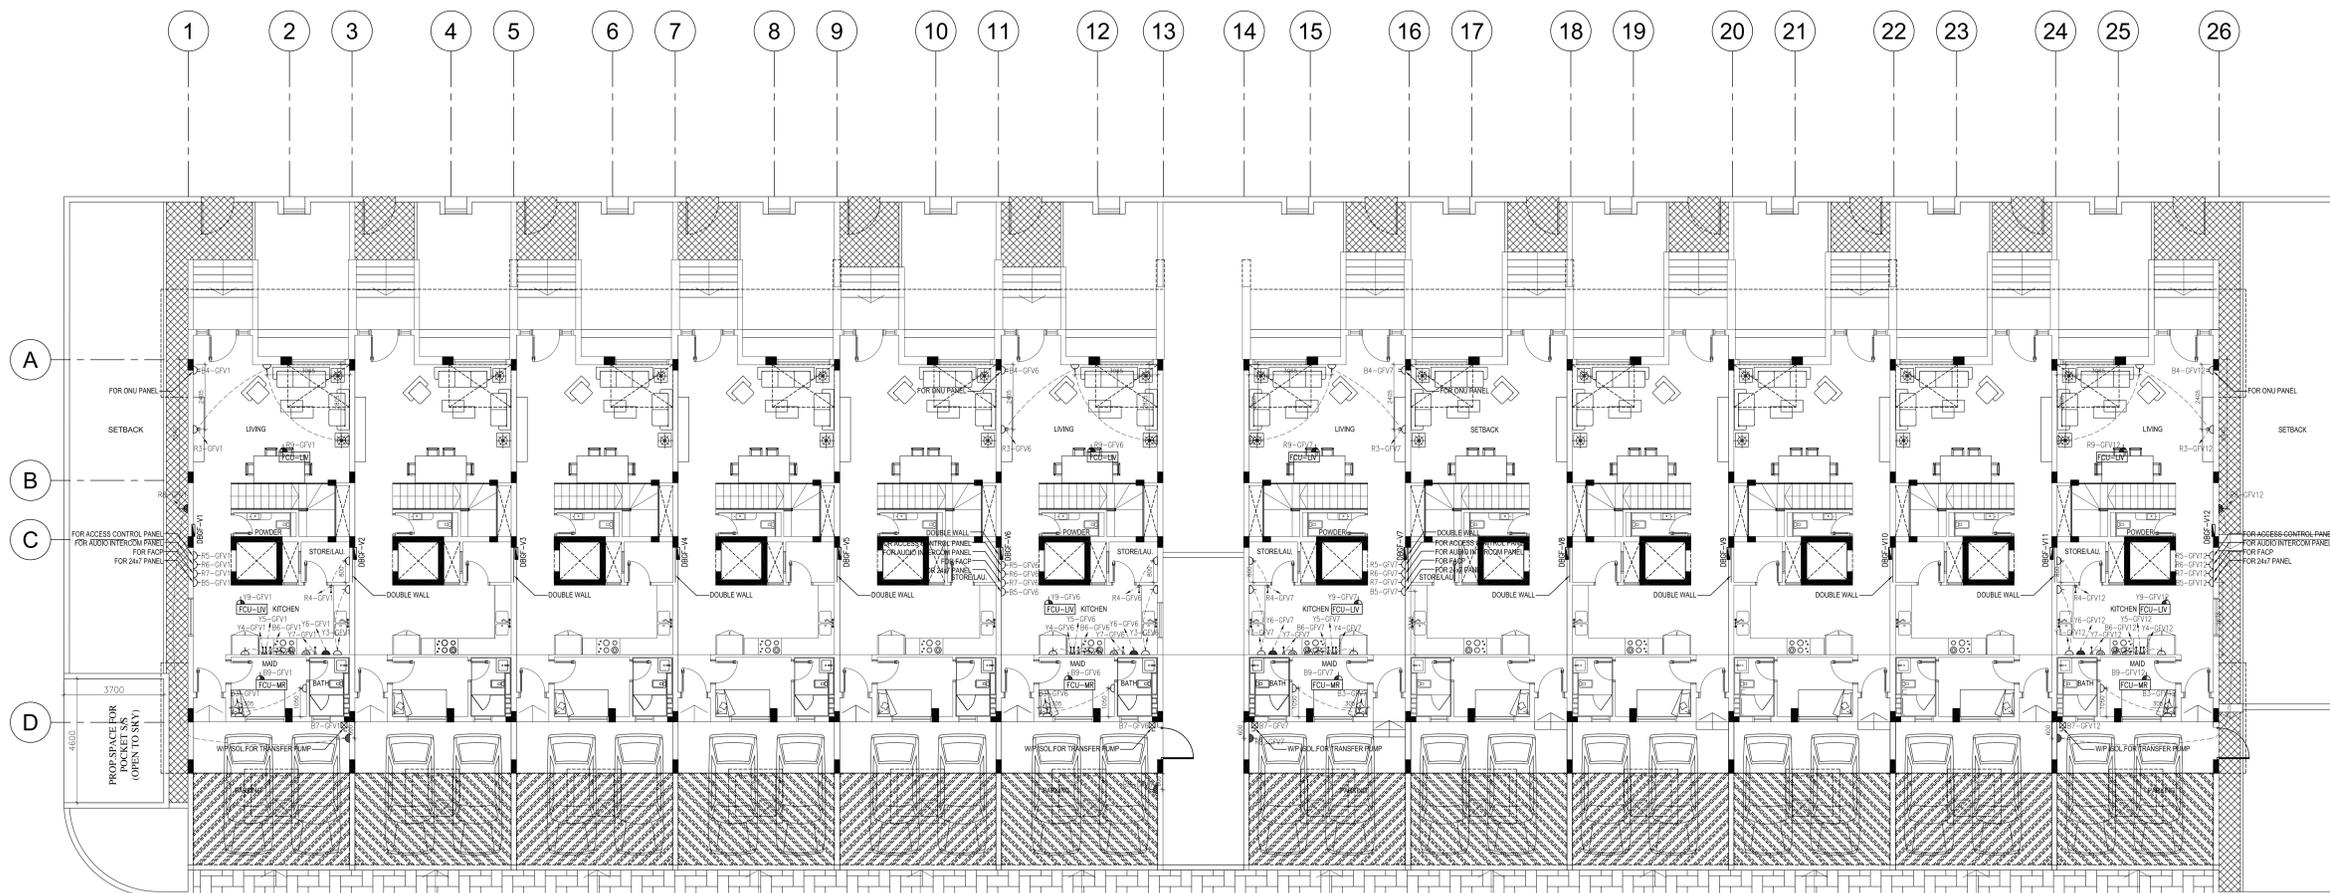

GROUND FLOOR POWER LAYOUT PLAN

NO.	DATE	BY	REVISION DETAILS
REVISIONS			

PROJECT:  
G+2 (12 NOS. TOWN HOUSES)  
BLOCK: AL BARSHA SOUTH 4TH PLOT: 6817078

CLIENT:  
PACIFIQUE GLOBAL PROPERTIES LLC

CONSULTANT :  
  
PARADISE HOME ENGINEERING CONSULTANCY  
Architecture & Engg. Consultants  
DUBAI Tel: 3575333  
Fax: 3575353 P.O. Box 22563

MEP CONSULTANT:  
  
BEC  
MEP DESIGN SUPERVISION  
P.O. Box : 114535, Dubai, U.A.E.  
Tel. : +971 4 2662650,  
Fax : +971 4 2662680,  
blazemiddleeast@gmail.com  
www.blazeengineeringme.com

MAIN CONT. :  
  
VISION HOUSE BUILDING CONTRACTING LLC  
فيجين هاوس لمقاولات البناء (ش.م.م.)  
VISION HOUSE BUILDING CONTRACTING LLC

VISION HOUSE BUILDING CONTRACTING  
P.O. BOX: 1909, DUBAI TEL: 04-2343355 FAX: 04-2343377


MEP CONT. :  
ELECTRIC CIRCLE TECHNICAL SERVICES LLC  
P.O. BOX 232522, DUBAI  
TEL: 042871919 FAX: 042870909 M: 0556452851  
Email: electriccirclellc@gmail.com

DRAWING TITLE  
GROUND FLOOR POWER LAYOUT PLAN

DATE : 17/06/2024	DESIGN: R.A.	DRAWING NO. EP-101
SCALE : 1:150	REVISION: 00	


LEGENDS:-

SYMBOL	DESCRIPTION
	MAIN DISTRIBUTION BOARD (MDB) IP55
	SUB MAIN DISTRIBUTION BOARD
	DISTRIBUTION BOARD (DB)
	CAPACITOR BANK
	LIGHTING CONTROL PANEL
	SINGLE PHASE ISOLATOR IP65
	THREE PHASE ISOLATOR IP65
	13A SINGLE SOCKET SINGLE SWITCHED OUTLET
	13A DOUBLE SOCKET SINGLE SWITCHED OUTLET
	20A SOCKET OUTLET
	SWITCHED FUSED SPUR OUTLET
	20A SOCKET OUTLET WITH DP SWITCH
	13A 2POLE & EARTH WEATHER PROOF SWITCH SOCKET OUTLET
	POWER CIRCUIT
	20A DP SWITCH WITH NEON INDICATOR WHD/WMDRYER/AC

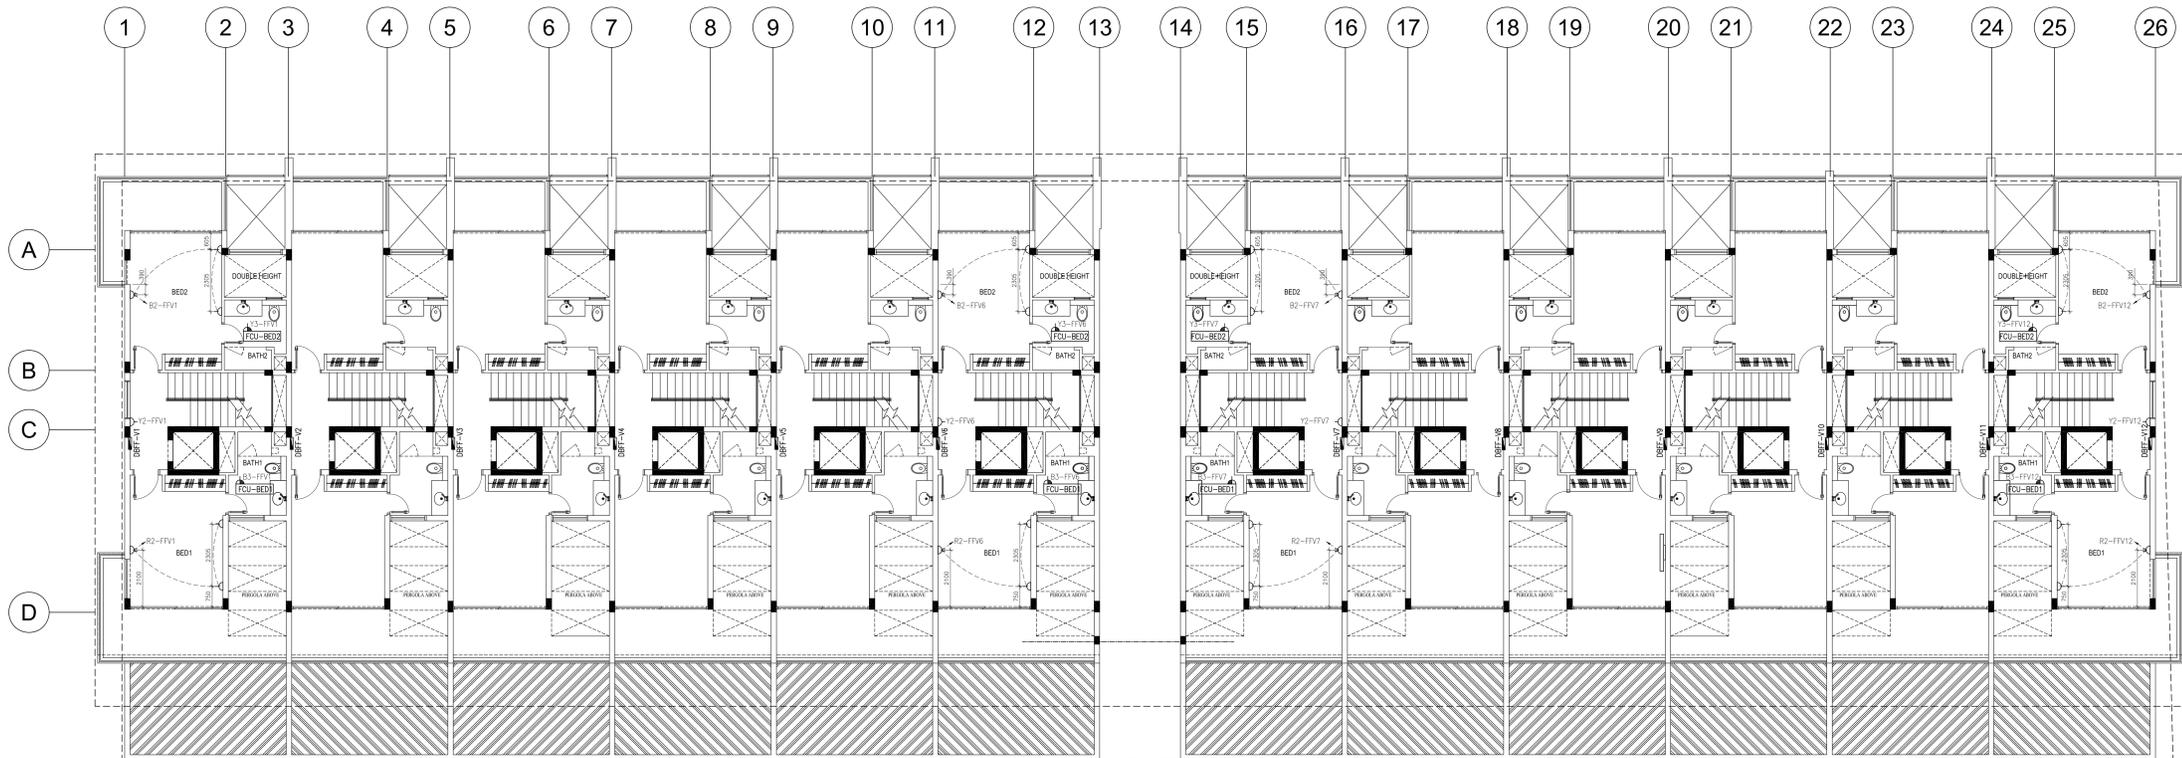

FIRST FLOOR POWER LAYOUT PLAN

NO.	DATE	BY	REVISION DETAILS
R E V I S I O N S			
PROJECT:			
G+2 (12 NOS. TOWN HOUSES)			
BLOCK: AL BARSHA SOUTH 4TH PLOT: 6817078			
CLIENT:			
PACIFIQUE GLOBAL PROPERTIES LLC			
CONSULTANT :			
 <b>PARADISE HOME ENGINEERING CONSULTANCY</b> Architecture & Engg. Consultants DUBAI Tel: 3575333 Fax: 3575353 P.O. Box 22563			
MEP CONSULTANT:			
 <b>BEC</b> MEP DESIGN SUPERVISION P.O. Box : 114535, Dubai, U.A.E. Tel. : +971 4 2662650, Fax : +971 4 2662680, blazemiddleeast@gmail.com www.blazeengineeringme.com			
MAIN CONT. :			
 <b>VISION HOUSE BUILDING CONTRACTING LLC</b> فيجين هاوس لمقاولات البناء (ش.ذ.م.) VISION HOUSE BUILDING CONTRACTING LLC P.O. BOX: 1909, DUBAI TEL: 04-2343355 FAX: 04-2343377			
MEP CONT. :			
<b>ELECTRIC CIRCLE TECHNICAL SERVICES LLC</b> P.O. BOX 232522, DUBAI TEL: 042871919 FAX: 042870909 M: 0556452851 Email: electriccirclellc@gmail.com			
DRAWING TITLE			
FIRST FLOOR POWER LAYOUT PLAN			
DATE :	DESIGN: R.A.	DRAWING NO.	
17/06/2024		EP-102	
SCALE : 1:150	REVISION: 00		

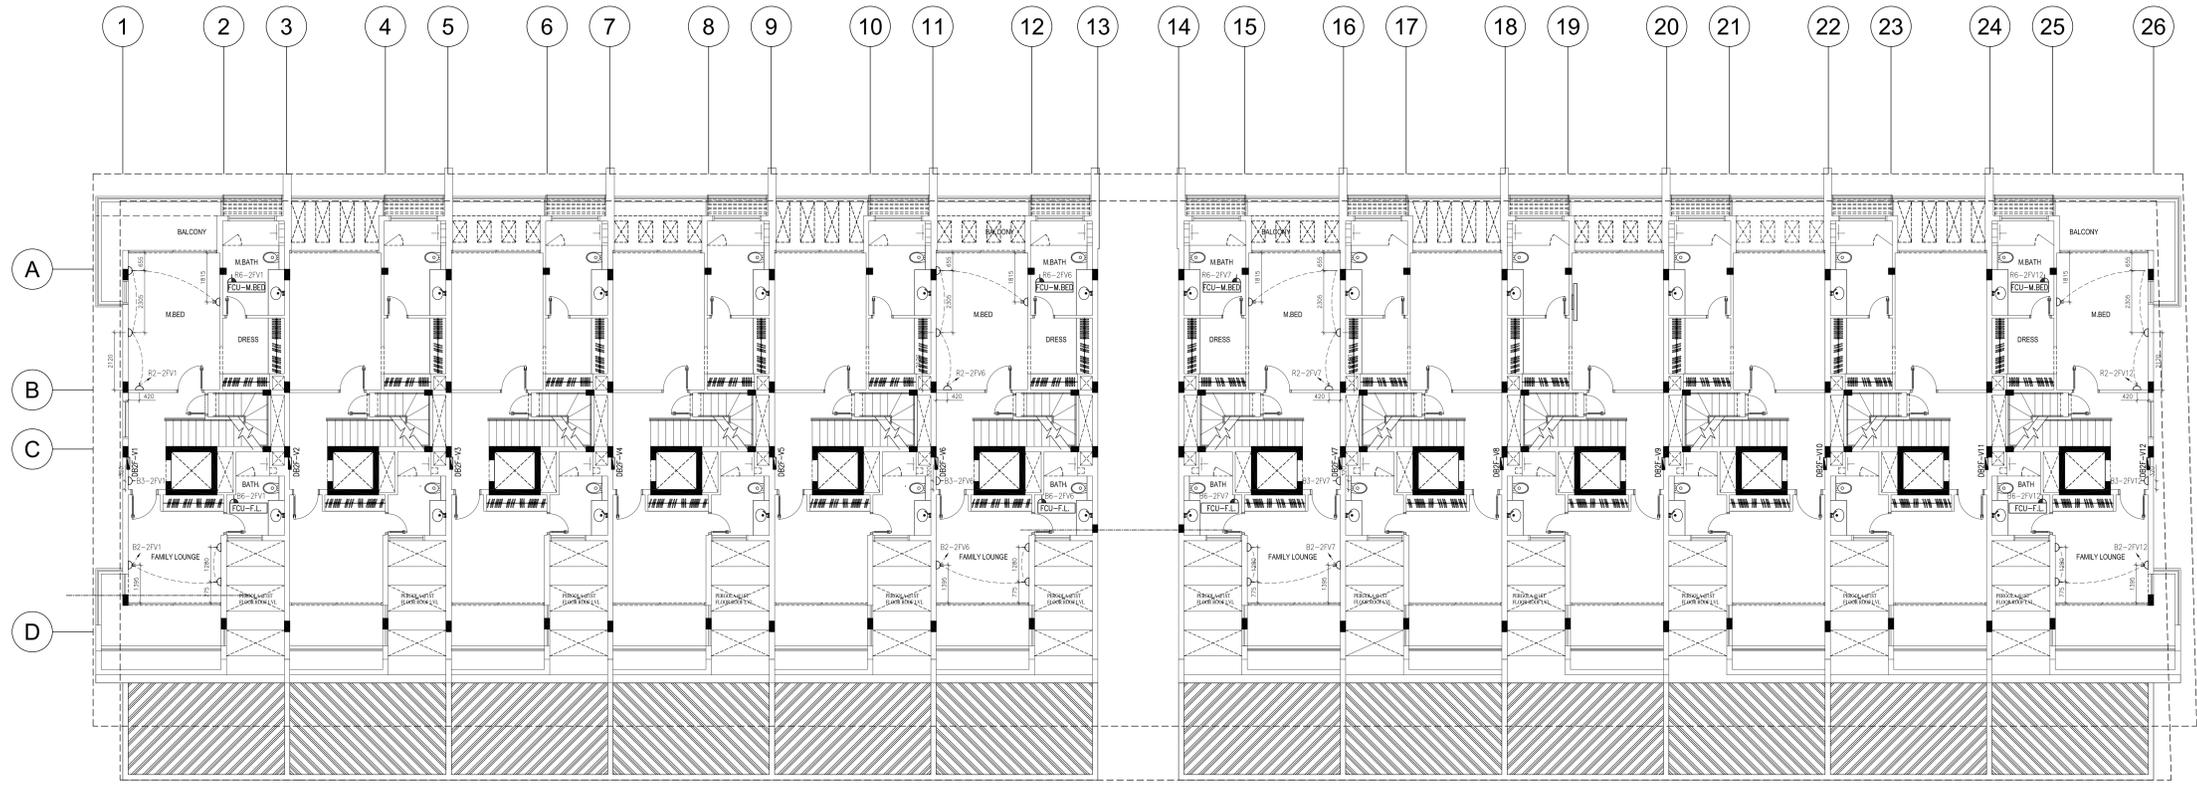


SECOND FLOOR POWER LAYOUT PLAN

LEGENDS-

SYMBOL	DESCRIPTION
	MAIN DISTRIBUTION BOARD (MDB) IP55
	SUB MAIN DISTRIBUTION BOARD
	DISTRIBUTION BOARD (DB)
	CAPACITOR BANK
	LIGHTING CONTROL PANEL
	SINGLE PHASE ISOLATOR IP65
	THREE PHASE ISOLATOR IP65
	13A SINGLE SOCKET SINGLE SWITCHED OUTLET
	13A DOUBLE SOCKET SINGLE SWITCHED OUTLET
	20A SOCKET OUTLET
	SWITCHED FUSED SPUR OUTLET
	20A SOCKET OUTLET WITH DP SWITCH
	13A 2POLE & EARTH WEATHER PROOF SOCKET OUTLET
	POWER CIRCUIT
	20A DP SWITCH WITH NEON INDICATOR
	WHD/WMD/RY/AC


NO.	DATE	BY	REVISION DETAILS
R E V I S I O N S			
PROJECT:			
G+2 (12 NOS. TOWN HOUSES)			
BLOCK: AL BARSHA SOUTH 4TH PLOT: 6817078			
CLIENT:			
PACIFIQUE GLOBAL PROPERTIES LLC			
CONSULTANT :			
 <b>PARADISE HOME ENGINEERING CONSULTANCY</b> Architecture & Engg. Consultants DUBAI Tel: 3575333 Fax: 3575353 P.O. Box 22563			
MEP CONSULTANT:			
 <b>BEC</b> MEP DESIGN SUPERVISION P.O. Box : 114535, Dubai, U.A.E. Tel. : +971 4 2662650, Fax : +971 4 2662680, blazemiddleeast@gmail.com www.blazeengineeringme.com			
MAIN CONT. :			
 <b>VISION HOUSE BUILDING CONTRACTING LLC</b> (ش.م.م.) فيجين هاوس لمقاولات البناء VISION HOUSE BUILDING CONTRACTING LLC			
VISION HOUSE BUILDING CONTRACTING			
P.O. BOX: 1909, DUBAI TEL: 04-2343355 FAX: 04-2343377			
MEP CONT. :			
ELECTRIC CIRCLE TECHNICAL SERVICES LLC			
P.O. BOX 232522, DUBAI			
TEL: 042871919 FAX: 042870909 M: 0556452851			
Email: electriccirclellc@gmail.com			
DRAWING TITLE			
SECOND FLOOR POWER LAYOUT PLAN			
DATE :	DESIGN: R.A.	DRAWING NO.	
17/06/2024		EP-103	
SCALE : 1:150	REVISION: 00		

SYMBOL	DESCRIPTION
	MAIN DISTRIBUTION BOARD (MDB) IP55
	SUB MAIN DISTRIBUTION BOARD
	DISTRIBUTION BOARD (DB)
	CAPACITOR BANK
	LIGHTING CONTROL PANEL
	SINGLE PHASE ISOLATOR IP65
	THREE PHASE ISOLATOR IP65
	13A SINGLE SOCKET SINGLE SWITCHED OUTLET
	13A DOUBLE SOCKET SINGLE SWITCHED OUTLET
	20A SOCKET OUTLET
	SWITCHED FUSED SPUR OUTLET
	20A SOCKET OUTLET WITH DP SWITCH
	13A 2-POLE & EARTH WEATHER PROOF SWITCH SOCKET OUTLET
	POWER CIRCUIT
	20A DP SWITCH WITH NEON INDICATOR WINDOW WDR/ERAC

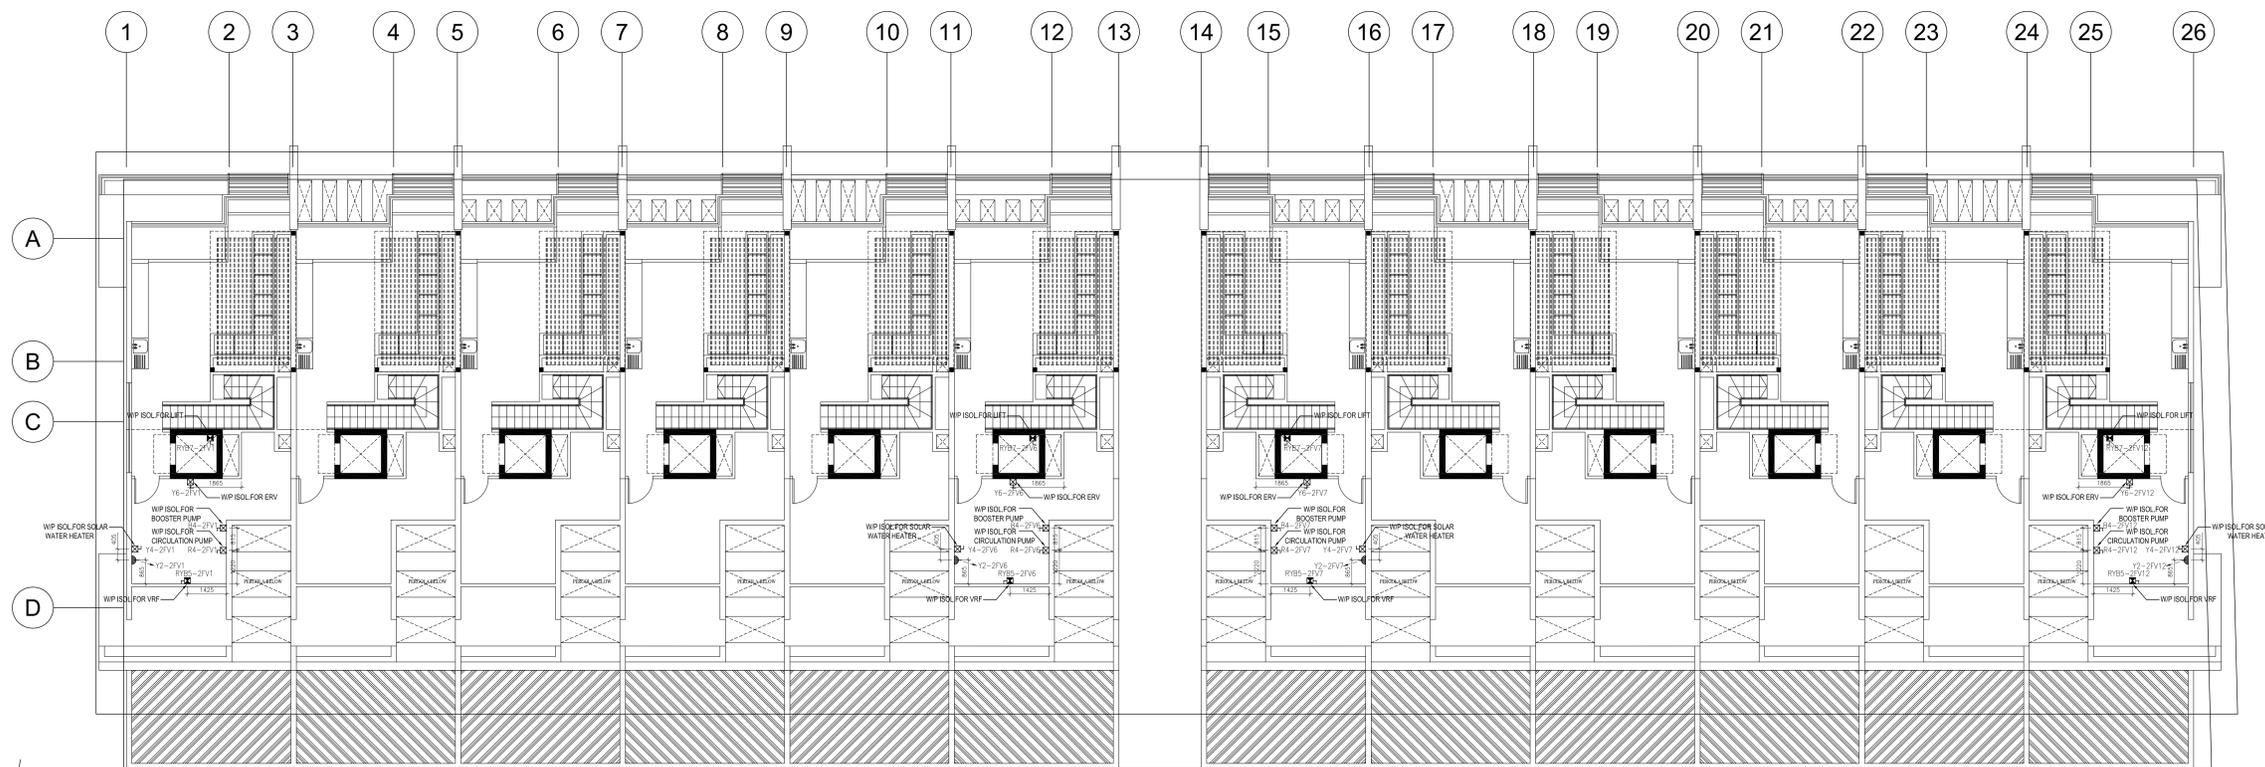


ROOF FLOOR POWER LAYOUT PLAN

NO.	DATE	BY	REVISION DETAILS
REVISIONS			
PROJECT:			
G+2 (12 NOS. TOWN HOUSES)			
BLOCK: AL BARSHA SOUTH 4TH PLOT: 6817078			
CLIENT:			
PACIFIQUE GLOBAL PROPERTIES LLC			
CONSULTANT :			
 <b>PARADISE HOME ENGINEERING CONSULTANCY</b> Architecture & Engg. Consultants DUBAI Tel: 3575333 Fax: 3575353 P.O. Box 22563			
MEP CONSULTANT:			
 <b>BEC</b> MEP DESIGN SUPERVISION P.O. Box : 114535, Dubai, U.A.E. Tel. : +971 4 2662650, Fax : +971 4 2662680, blazemiddleeast@gmail.com www.blazeengineeringme.com			
MAIN CONT. :			
 <b>VISION HOUSE BUILDING CONTRACTING LLC</b> فيجين هاوس لمقاولات البناء (ش.م.م.) VISION HOUSE BUILDING CONTRACTING LLC P.O. BOX: 1909, DUBAI TEL: 04-2343355 FAX: 04-2343377			
MEP CONT. :			
<b>ELECTRIC CIRCLE TECHNICAL SERVICES LLC</b> P.O. BOX 232522, DUBAI TEL: 042871919 FAX: 042870909 M: 0556452851 Email: electriccirclellc@gmail.com			
DRAWING TITLE			
ROOF FLOOR POWER LAYOUT PLAN			
DATE :	DESIGN: R.A.	DRAWING NO.	
17/06/2024		EP-104	
SCALE : 1:150	REVISION: 00		

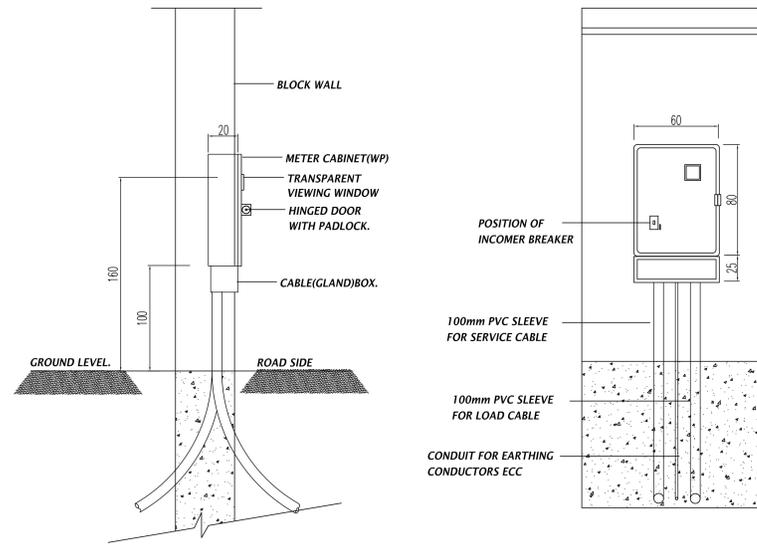

METER ENCLOSURE INSTALLATION DETAILS

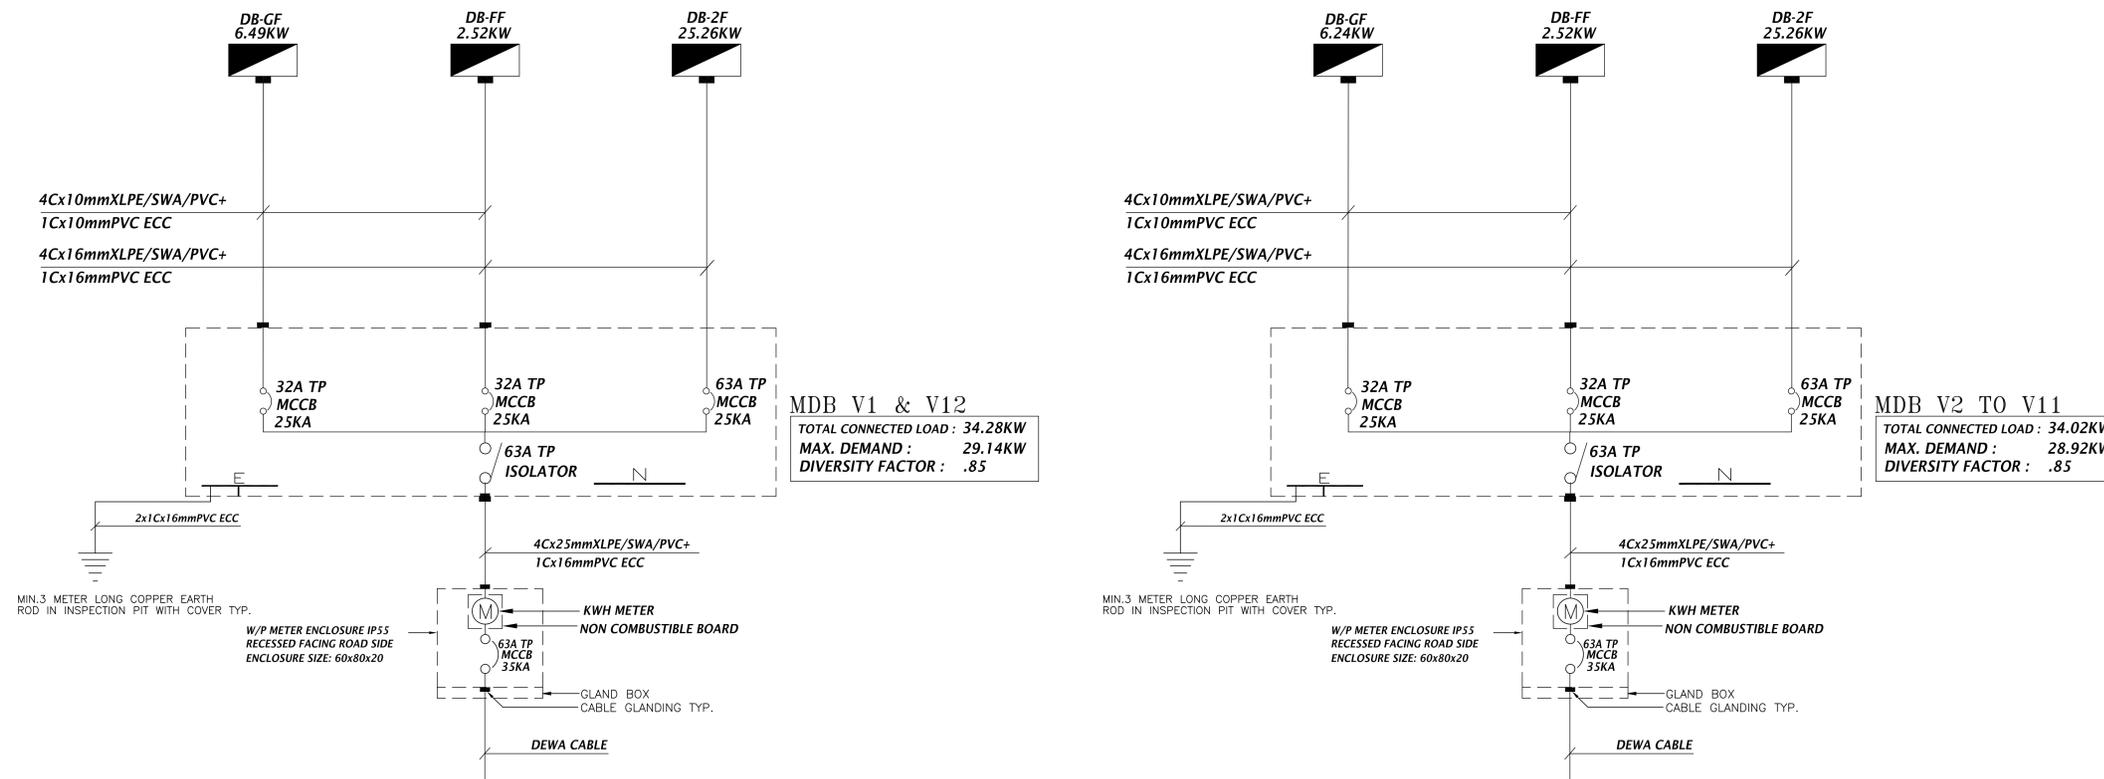

SINGLE LINE DIAGRAM

NO.	DATE	BY	REVISION DETAILS
R E V I S I O N S			
PROJECT:			
G+2 (12 NOS.TOWN HOUSES)			
BLOCK: AL BARSHA SOUTH 4TH PLOT: 6817078			
CLIENT:			
PACIFIQUE GLOBAL PROPERTIES LLC			
CONSULTANT :			
 <b>PARADISE HOME ENGINEERING CONSULTANCY</b> Architecture & Engg. Consultants DUBAI Tel: 3575333 Fax: 3575353 P.O. Box 22563			
MEP CONSULTANT:			
 <b>BEC</b> MEP DESIGN SUPERVISION			
P.O. Box : 114535, Dubai, U.A.E. Tel. : +971 4 2662650, Fax : +971 4 2662680, blazemiddleeast@gmail.com www.blazeengineeringme.com			
MAIN CONT. :			
 <b>VISION HOUSE BUILDING CONTRACTING LLC</b> فيجين هاوس لمقاولات البناء (ش.ذ.م.) VISION HOUSE BUILDING CONTRACTING LLC			
VISION HOUSE BUILDING CONTRACTING P.O.BOX: 1909, DUBAI TEL: 04-2343355 FAX: 04-2343377			
MEP CONT. :			
ELECTRIC CIRCLE TECHNICAL SERVICES LLC P.O. BOX 232522, DUBAI TEL: 042871919 FAX: 042870909 M: 0556452851 Email: electriccirclellc@gmail.com			
DRAWING TITLE			
SINGLE LINE DIAGRAM			
DATE :	DESIGN: R.A.	DRAWING NO.	
17/06/2024		EP-105	
SCALE : 1:150	REVISION: 00		