






12 11 10 9 8 7 6 5 4 3 2 1

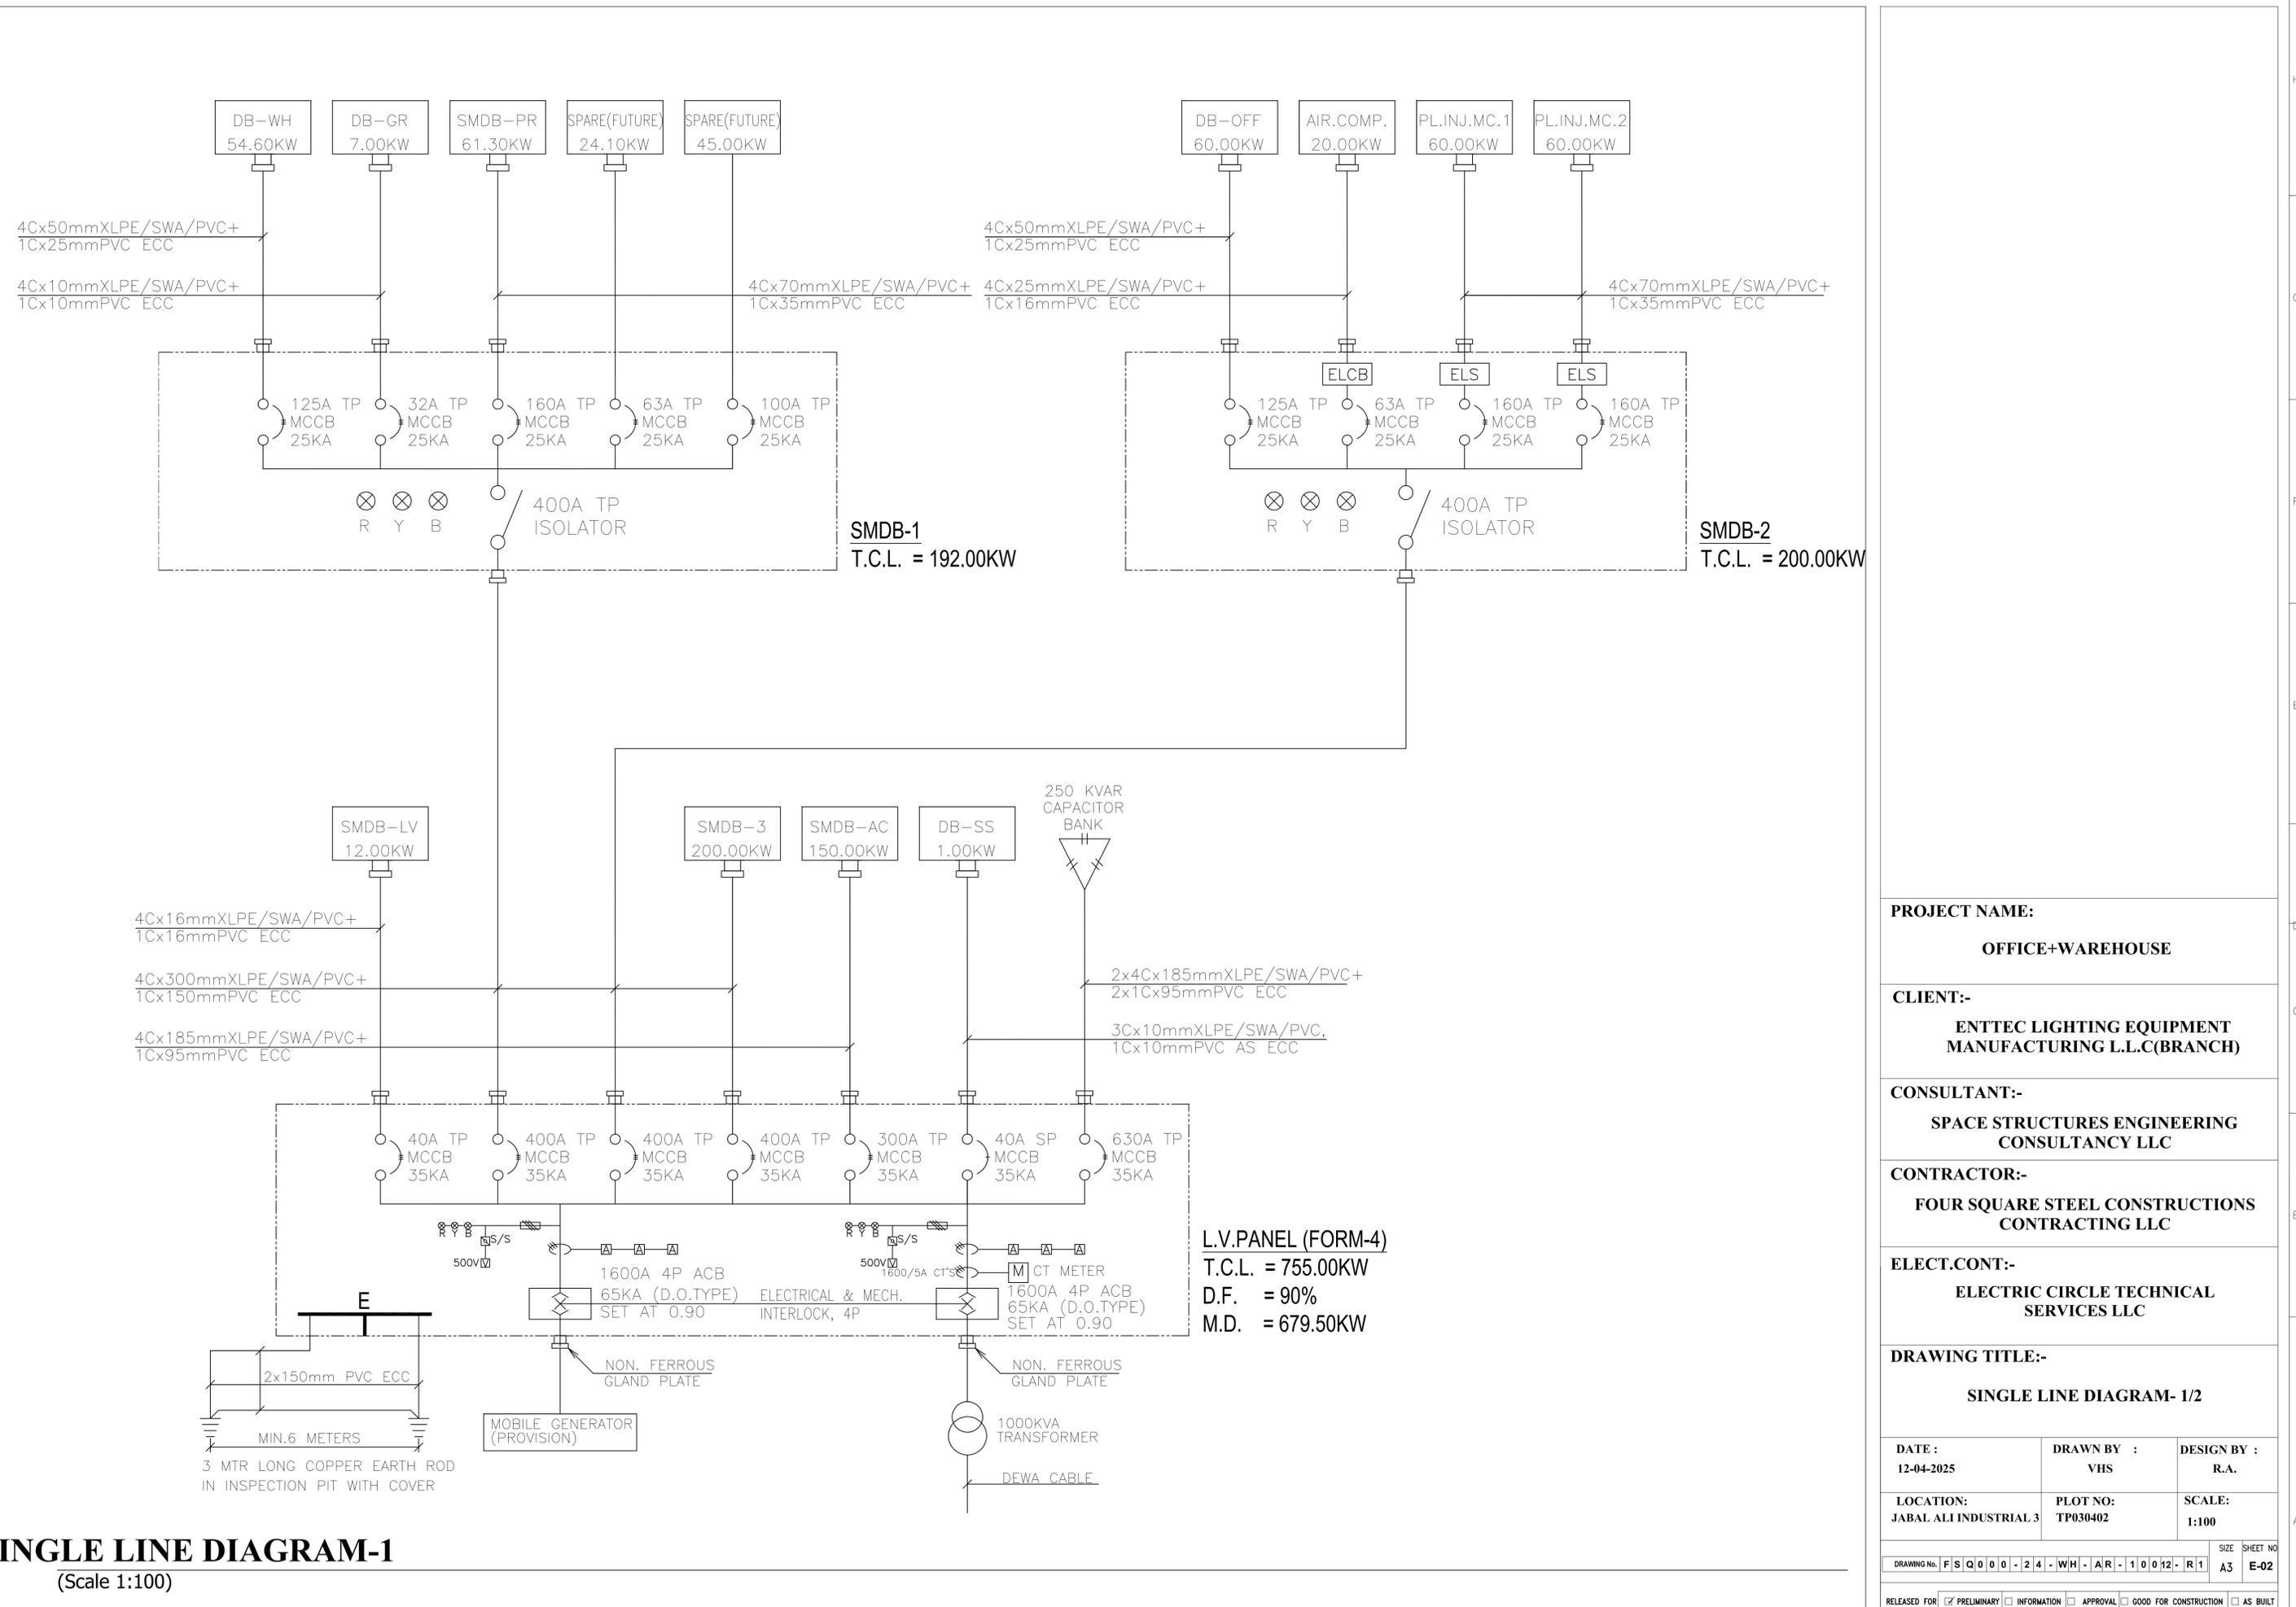

SINGLE LINE DIAGRAM-1
(Scale 1:100)

PROJECT NAME:										
OFFICE+WAREHOUSE										
CLIENT:-										
ENTTEC LIGHTING EQUIPMENT MANUFACTURING L.L.C(BRANCH)										
CONSULTANT:-										
SPACE STRUCTURES ENGINEERING CONSULTANCY LLC										
CONTRACTOR:-										
FOUR SQUARE STEEL CONSTRUCTIONS CONTRACTING LLC										
ELECT.CONT:-										
ELECTRIC CIRCLE TECHNICAL SERVICES LLC										
DRAWING TITLE:-										
SINGLE LINE DIAGRAM- 1/2										
DATE : 12-04-2025	DRAWN BY : VHS	DESIGN BY : R.A.								
LOCATION: JABAL ALI INDUSTRIAL 3	PLOT NO: TP030402	SCALE: 1:100								
<table border="1" style="width: 100%; border-collapse: collapse;"> <tr> <td style="font-size: 8px;">DRAWING No.</td> <td style="font-size: 8px;">F S Q 0 0 0 2 4 - W H - A R - 1 0 0 12 - R 1</td> <td style="font-size: 8px;">SIZE</td> <td style="font-size: 8px;">SHEET NO</td> </tr> <tr> <td></td> <td></td> <td style="font-size: 8px;">A3</td> <td style="font-size: 8px;">E-02</td> </tr> </table>			DRAWING No.	F S Q 0 0 0 2 4 - W H - A R - 1 0 0 12 - R 1	SIZE	SHEET NO			A3	E-02
DRAWING No.	F S Q 0 0 0 2 4 - W H - A R - 1 0 0 12 - R 1	SIZE	SHEET NO							
		A3	E-02							
<table border="0" style="width: 100%; font-size: 8px;"> <tr> <td>RELEASED FOR:</td> <td><input checked="" type="checkbox"/> PRELIMINARY</td> <td><input type="checkbox"/> INFORMATION</td> <td><input type="checkbox"/> APPROVAL</td> <td><input type="checkbox"/> GOOD FOR CONSTRUCTION</td> <td><input type="checkbox"/> AS BUILT</td> </tr> </table>			RELEASED FOR:	<input checked="" type="checkbox"/> PRELIMINARY	<input type="checkbox"/> INFORMATION	<input type="checkbox"/> APPROVAL	<input type="checkbox"/> GOOD FOR CONSTRUCTION	<input type="checkbox"/> AS BUILT		
RELEASED FOR:	<input checked="" type="checkbox"/> PRELIMINARY	<input type="checkbox"/> INFORMATION	<input type="checkbox"/> APPROVAL	<input type="checkbox"/> GOOD FOR CONSTRUCTION	<input type="checkbox"/> AS BUILT					

12 11 10 9 8 7 6 5 4 3 2 1

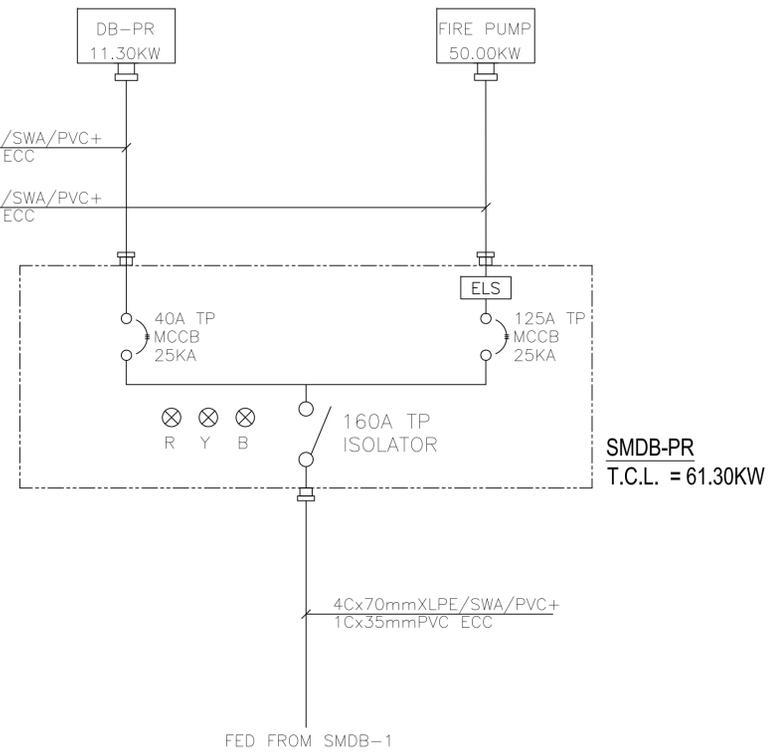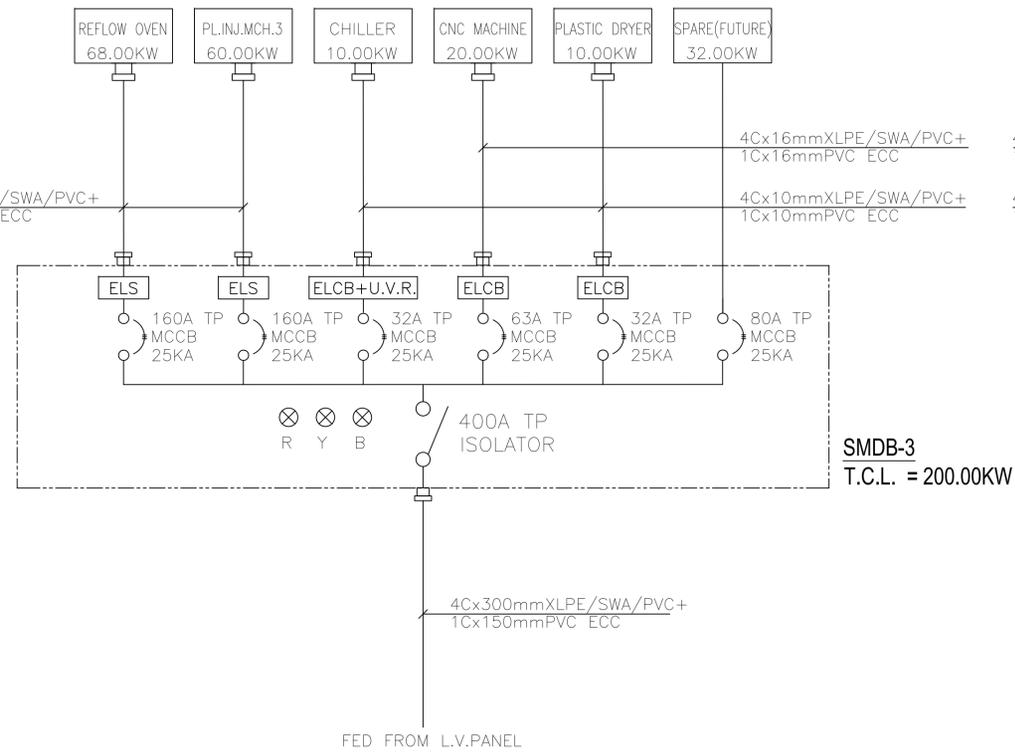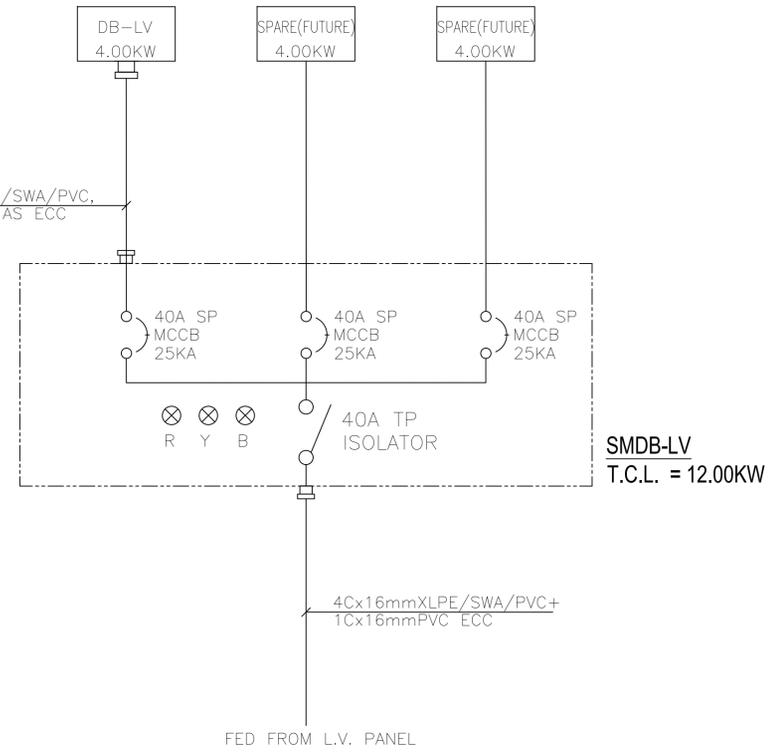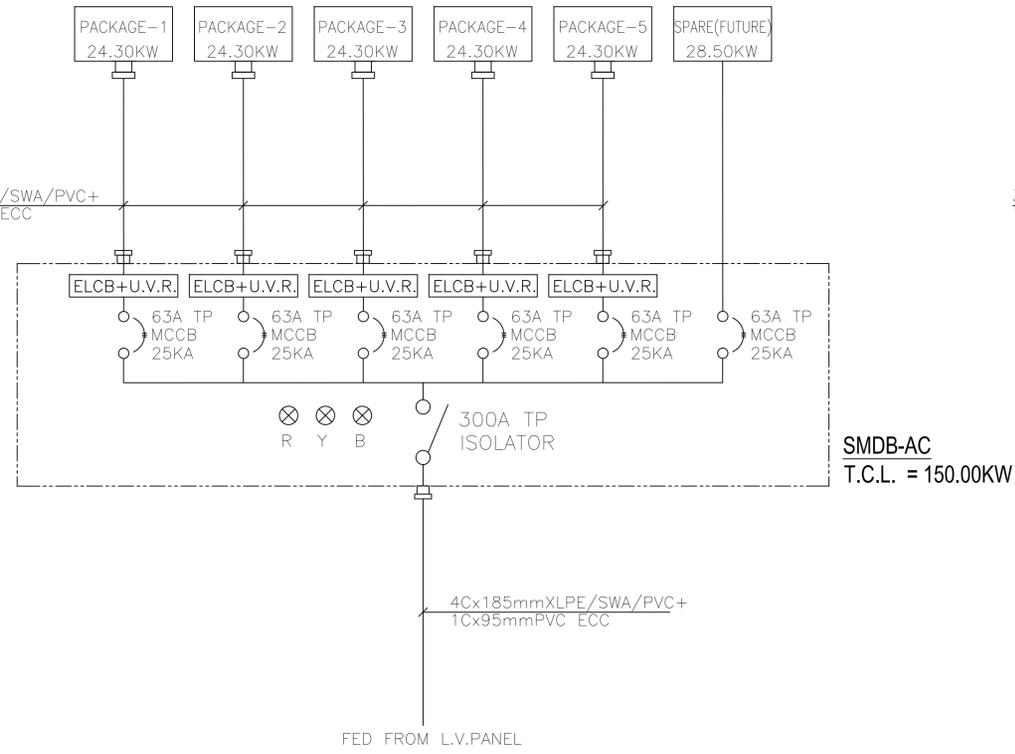

SINGLE LINE DIAGRAM-2
(Scale 1:100)

PROJECT NAME:
OFFICE+WAREHOUSE

CLIENT:-
ENTTEC LIGHTING EQUIPMENT
MANUFACTURING L.L.C(BRANCH)




CONSULTANT:-
SPACE STRUCTURES ENGINEERING
CONSULTANCY LLC

CONTRACTOR:-
FOUR SQUARE STEEL CONSTRUCTIONS
CONTRACTING LLC

ELECT.CONT:-
ELECTRIC CIRCLE TECHNICAL
SERVICES LLC

DRAWING TITLE:-
SINGLE LINE DIAGRAM-2/2

DATE : 12-04-2025	DRAWN BY : VHS	DESIGN BY : R.A.
LOCATION: JABAL ALI INDUSTRIAL 3	PLOT NO: TP030402	SCALE: 1:100
DRAWING No. F S Q 0 0 0 - 2 4 - W H - A R - 1 0 0 1 3 - R 1		SIZE SHEET NO A3 E-03
RELEASED FOR: <input checked="" type="checkbox"/> PRELIMINARY <input type="checkbox"/> INFORMATION <input type="checkbox"/> APPROVAL <input type="checkbox"/> GOOD FOR CONSTRUCTION <input type="checkbox"/> AS BUILT		

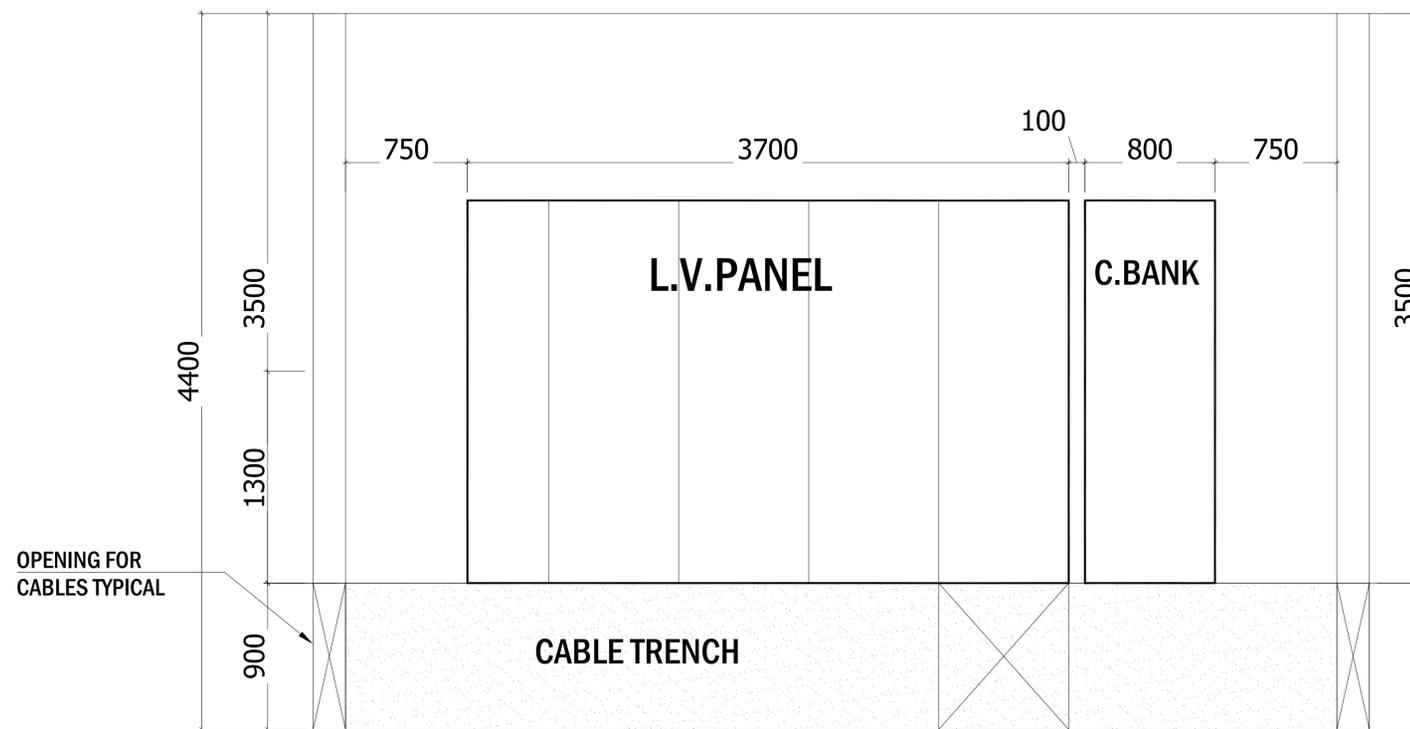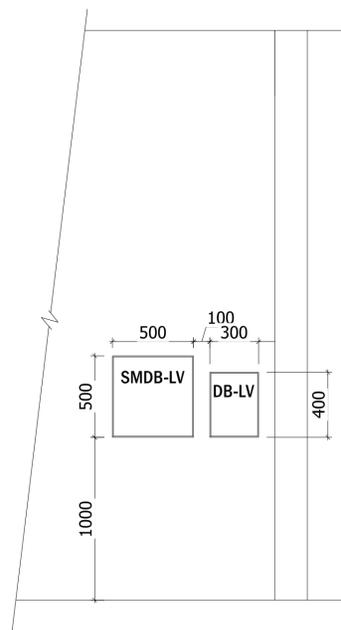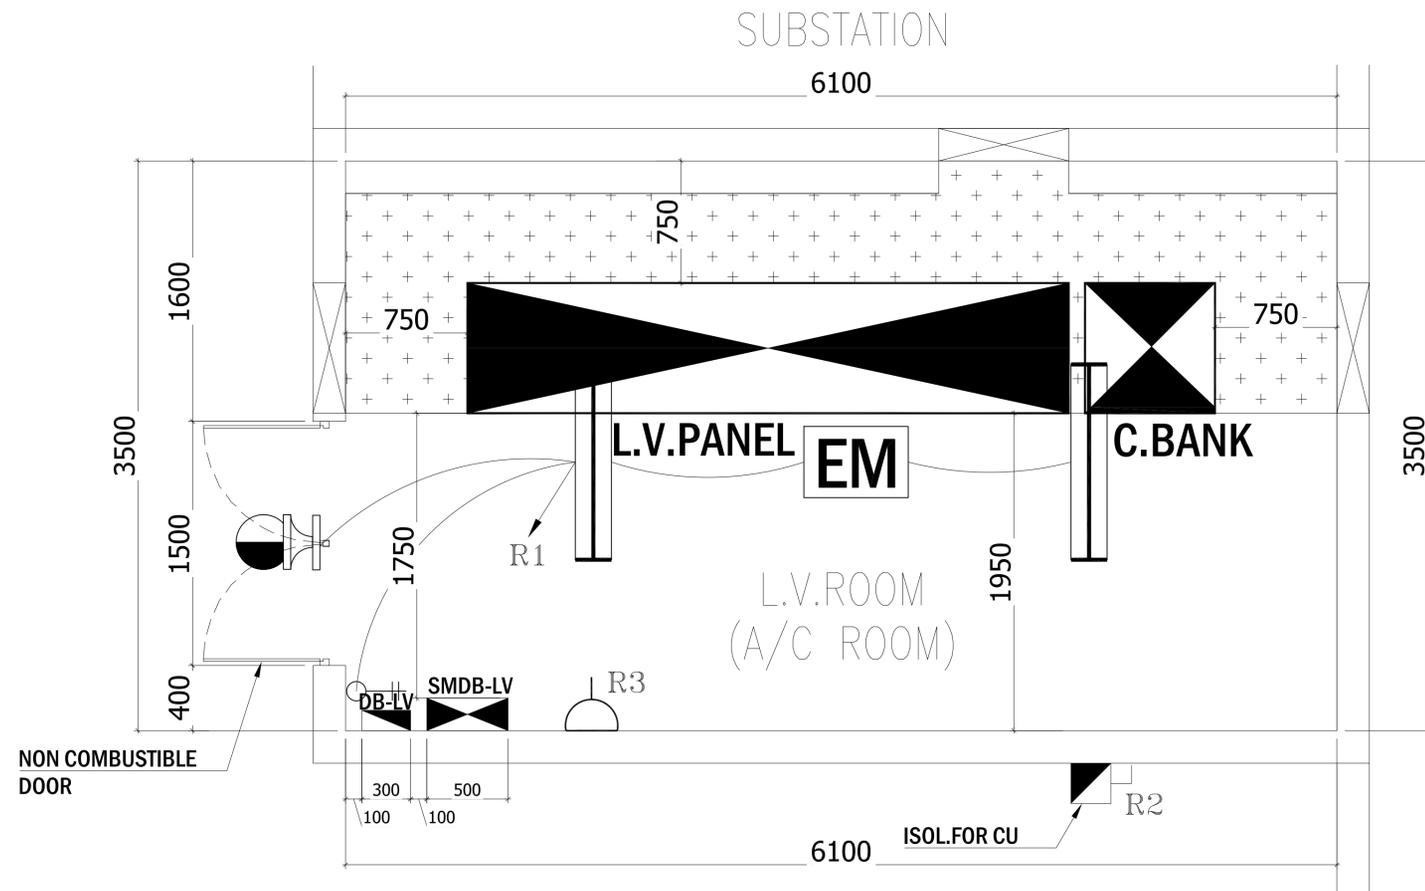

L.V.ROOM DETAILS

NTS

PROJECT NAME:-
OFFICE+WAREHOUSE

CLIENT:-
ENTTEC LIGHTING EQUIPMENT
MANUFACTURING L.L.C(BRANCH)


CONSULTANT:-
SPACE STRUCTURES ENGINEERING
CONSULTANCY LLC

CONTRACTOR:-
FOUR SQUARE STEEL CONSTRUCTIONS
CONTRACTING LLC

ELECT.CONT:-
ELECTRIC CIRCLE TECHNICAL
SERVICES LLC

DRAWING TITLE:-
L.V.ROOM DETAILS

DATE : 12-04-2025	DRAWN BY : VHS	DESIGN BY : R.A.
LOCATION: JABAL ALI INDUSTRIAL 3	PLOT NO: TP030402	SCALE: 1:100
DRAWING No. F S Q 0 0 0 - 2 4 - W H - A R - 1 0 0 6 - R 1		SIZE SHEET NO A3 E-04
RELEASED FOR: <input checked="" type="checkbox"/> PRELIMINARY <input type="checkbox"/> INFORMATION <input type="checkbox"/> APPROVAL <input type="checkbox"/> GOOD FOR CONSTRUCTION <input type="checkbox"/> AS BUILT		

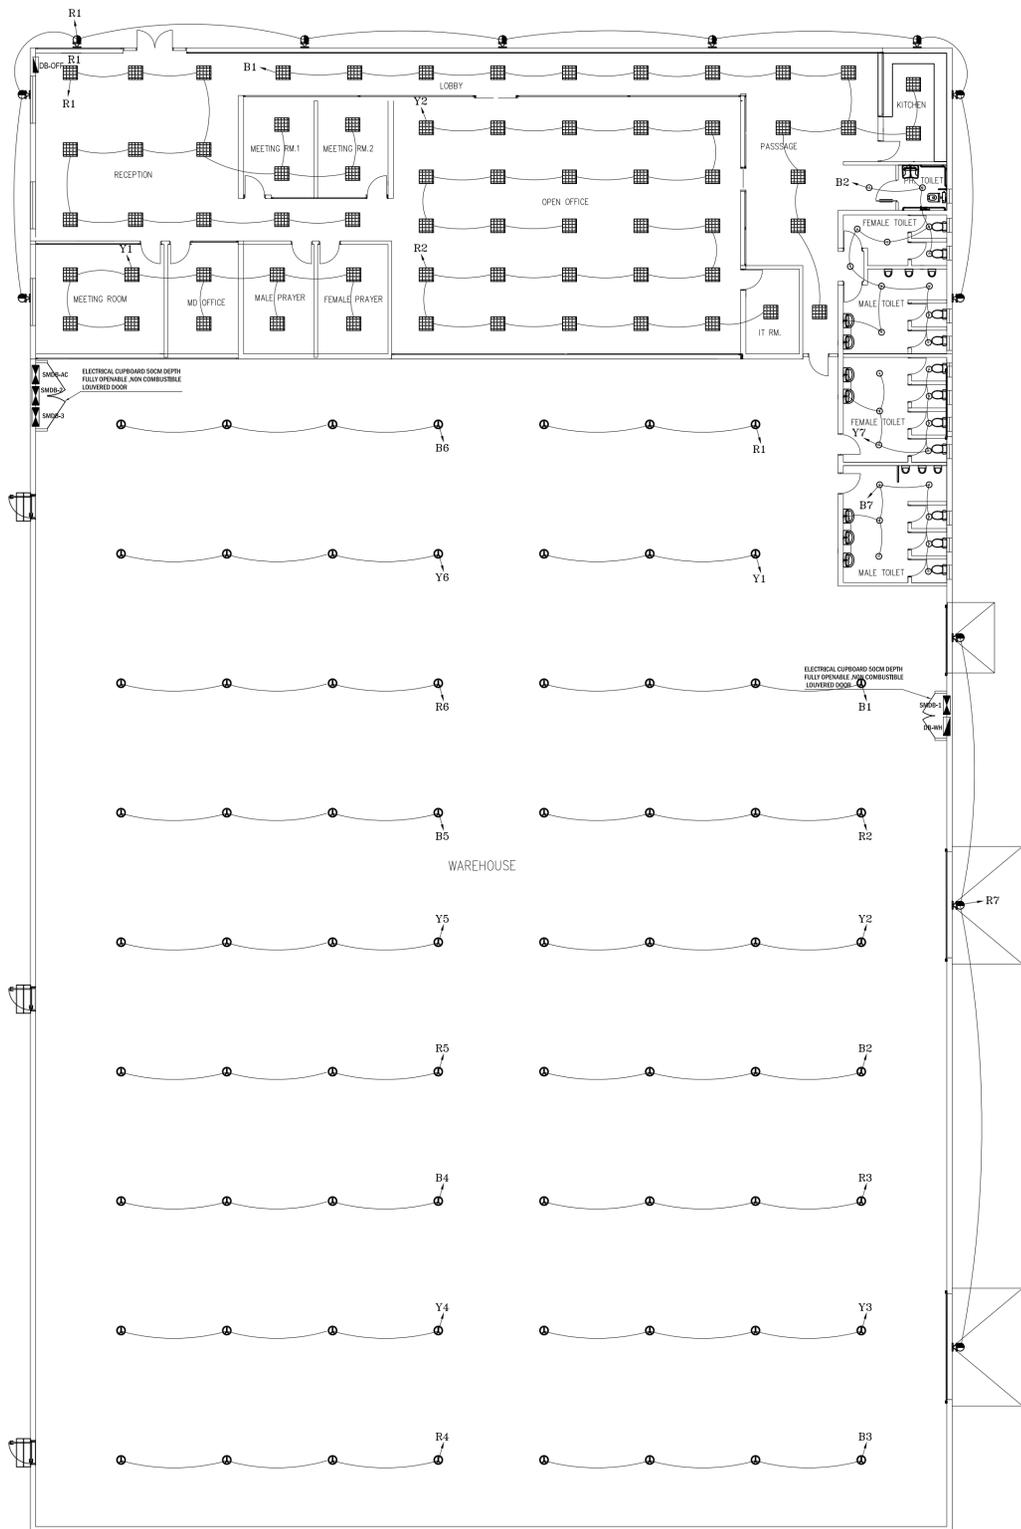

LIGHTING PLAN

(Scale 1:100)

PROJECT NAME:-
OFFICE+WAREHOUSE

CLIENT:-
ENTTEC LIGHTING EQUIPMENT
MANUFACTURING L.L.C(BRANCH)


CONSULTANT:-
SPACE STRUCTURES ENGINEERING
CONSULTANCY LLC

CONTRACTOR:-
FOUR SQUARE STEEL CONSTRUCTIONS
CONTRACTING LLC

ELECT.CONT:-
ELECTRIC CIRCLE TECHNICAL
SERVICES LLC

DRAWING TITLE:-
LIGHTING LAYOUT PLAN

DATE : 12-04-2025	DRAWN BY : VHS	DESIGN BY : R.A.
LOCATION: JABAL ALI INDUSTRIAL 3	PLOT NO: TP030402	SCALE: 1:100
DRAWING No. F S Q 0 0 0 - 2 4 - W H - A R - 1 0 0 5 - R 1		SIZE SHEET NO A3 E-05
RELEASED FOR: <input checked="" type="checkbox"/> PRELIMINARY <input type="checkbox"/> INFORMATION <input type="checkbox"/> APPROVAL <input type="checkbox"/> GOOD FOR CONSTRUCTION <input type="checkbox"/> AS BUILT		

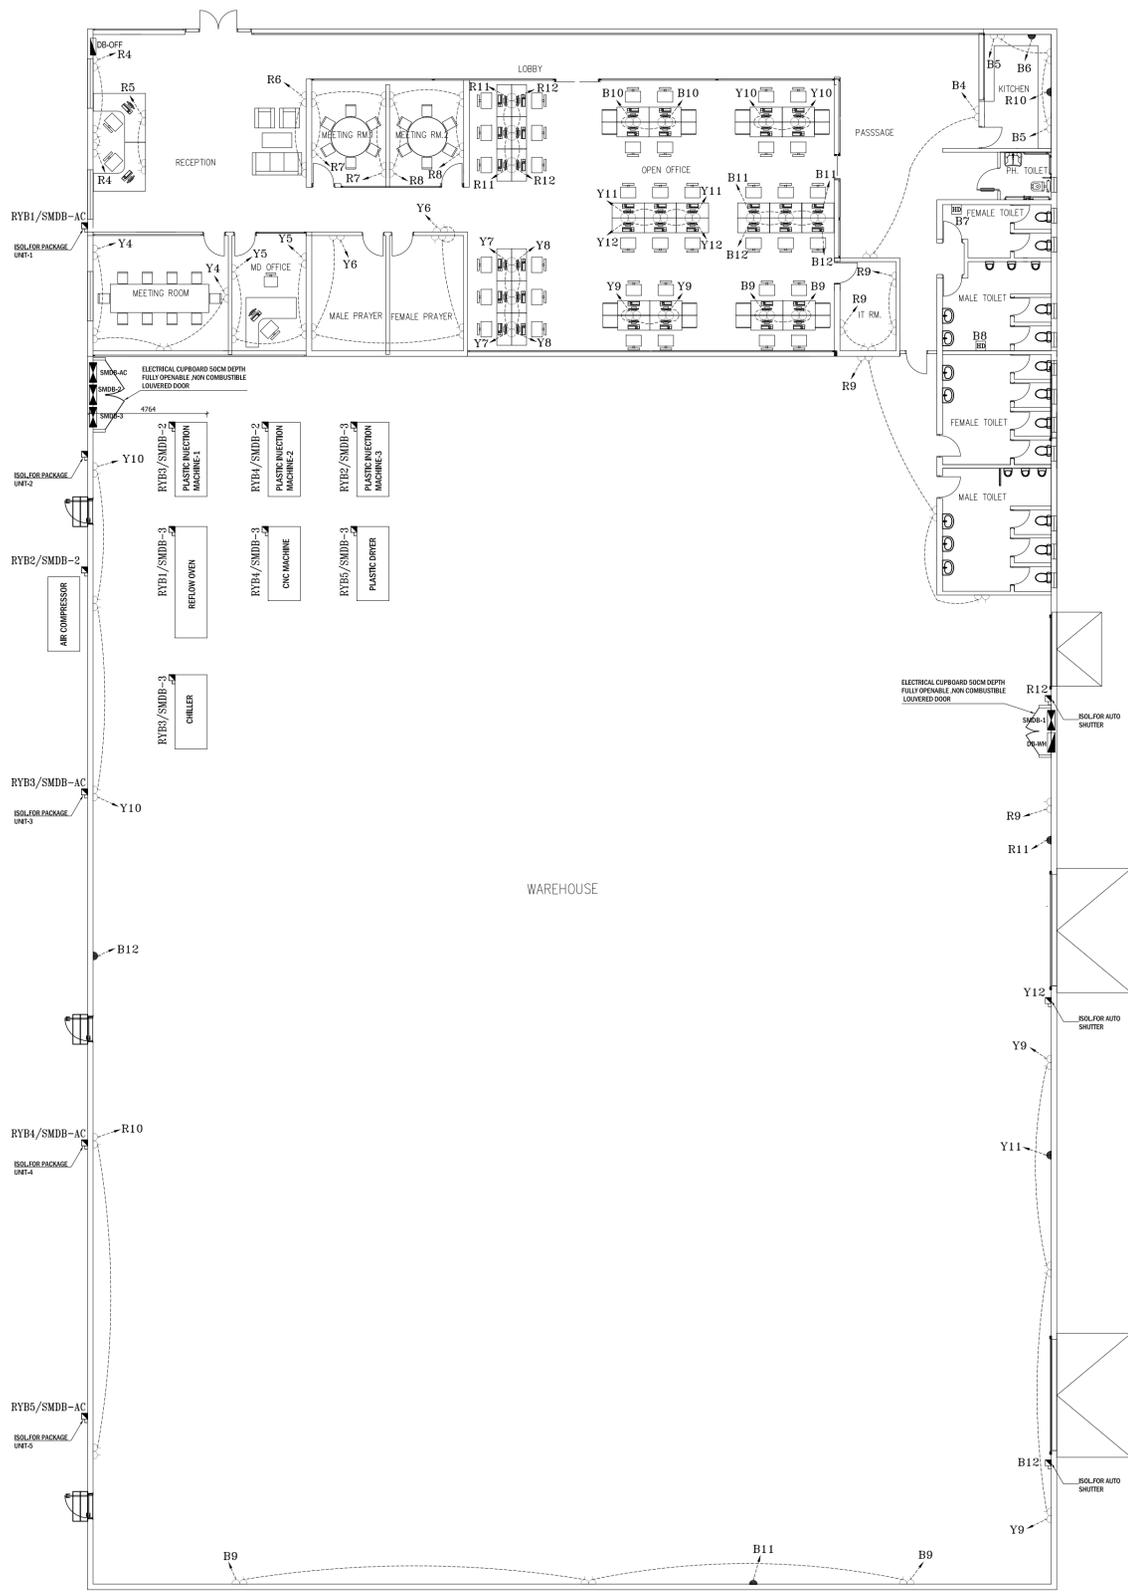

POWER PLAN
(Scale 1:100)

PROJECT NAME:-
OFFICE+WAREHOUSE

CLIENT:-
ENTTEC LIGHTING EQUIPMENT MANUFACTURING L.L.C(BRANCH)







CONSULTANT:-
SPACE STRUCTURES ENGINEERING CONSULTANCY LLC

CONTRACTOR:-
FOUR SQUARE STEEL CONSTRUCTIONS CONTRACTING LLC

ELECT.CONT:-
ELECTRIC CIRCLE TECHNICAL SERVICES LLC

DRAWING TITLE:-
POWER LAYOUT PLAN

DATE : 12-04-2025	DRAWN BY : VHS	DESIGN BY : R.A.
LOCATION: JABAL ALI INDUSTRIAL 3	PLOT NO: TP030402	SCALE: 1:100
DRAWING No. F S Q 0 0 0 - 2 4 - W H - A R - 1 0 0 6 - R 1		SIZE SHEET NO A3 E-06
RELEASED FOR: <input checked="" type="checkbox"/> PRELIMINARY <input type="checkbox"/> INFORMATION <input type="checkbox"/> APPROVAL <input type="checkbox"/> GOOD FOR CONSTRUCTION <input type="checkbox"/> AS BUILT		

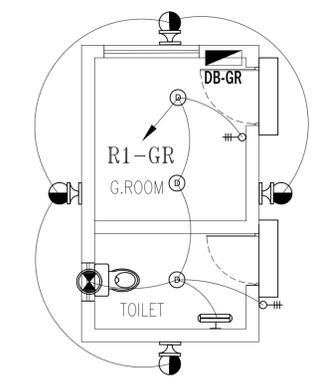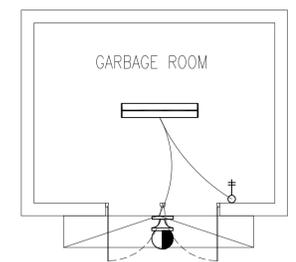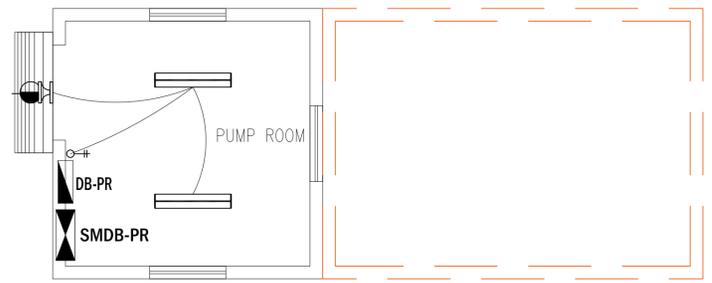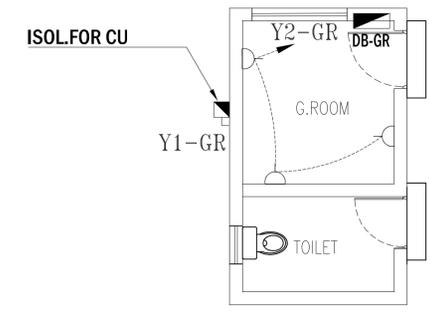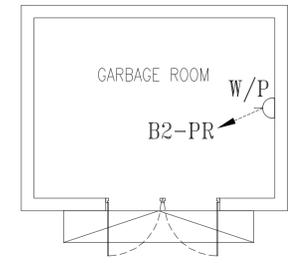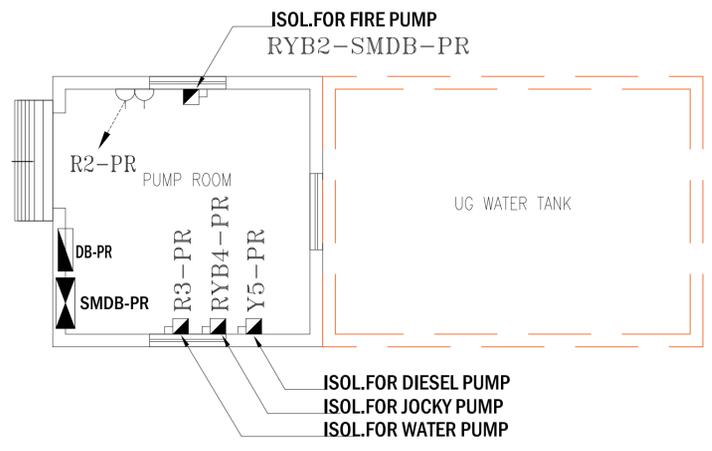

SERVICES LIGHTING & POWER PLAN
(Scale 1:100)

PROJECT NAME:-
OFFICE+WAREHOUSE

CLIENT:-
ENTTEC LIGHTING EQUIPMENT
MANUFACTURING L.L.C(BRANCH)

CONSULTANT:-
SPACE STRUCTURES ENGINEERING
CONSULTANCY LLC

CONTRACTOR:-
FOUR SQUARE STEEL CONSTRUCTIONS
CONTRACTING LLC

ELECT.CONT:-
ELECTRIC CIRCLE TECHNICAL
SERVICES LLC

DRAWING TITLE:-
SERVICES LIGHTING & POWER PLAN

DATE : 12-04-2025	DRAWN BY : VHS	DESIGN BY : R.A.
LOCATION: JABAL ALI INDUSTRIAL 3	PLOT NO: TP030402	SCALE: 1:100
DRAWING No. F S Q 0 0 0 - 2 4 - W H - A R - 1 0 0 1 1 - R 1		SIZE SHEET NO A3 E-07
RELEASED FOR: <input checked="" type="checkbox"/> PRELIMINARY <input type="checkbox"/> INFORMATION <input type="checkbox"/> APPROVAL <input type="checkbox"/> GOOD FOR CONSTRUCTION <input type="checkbox"/> AS BUILT		